
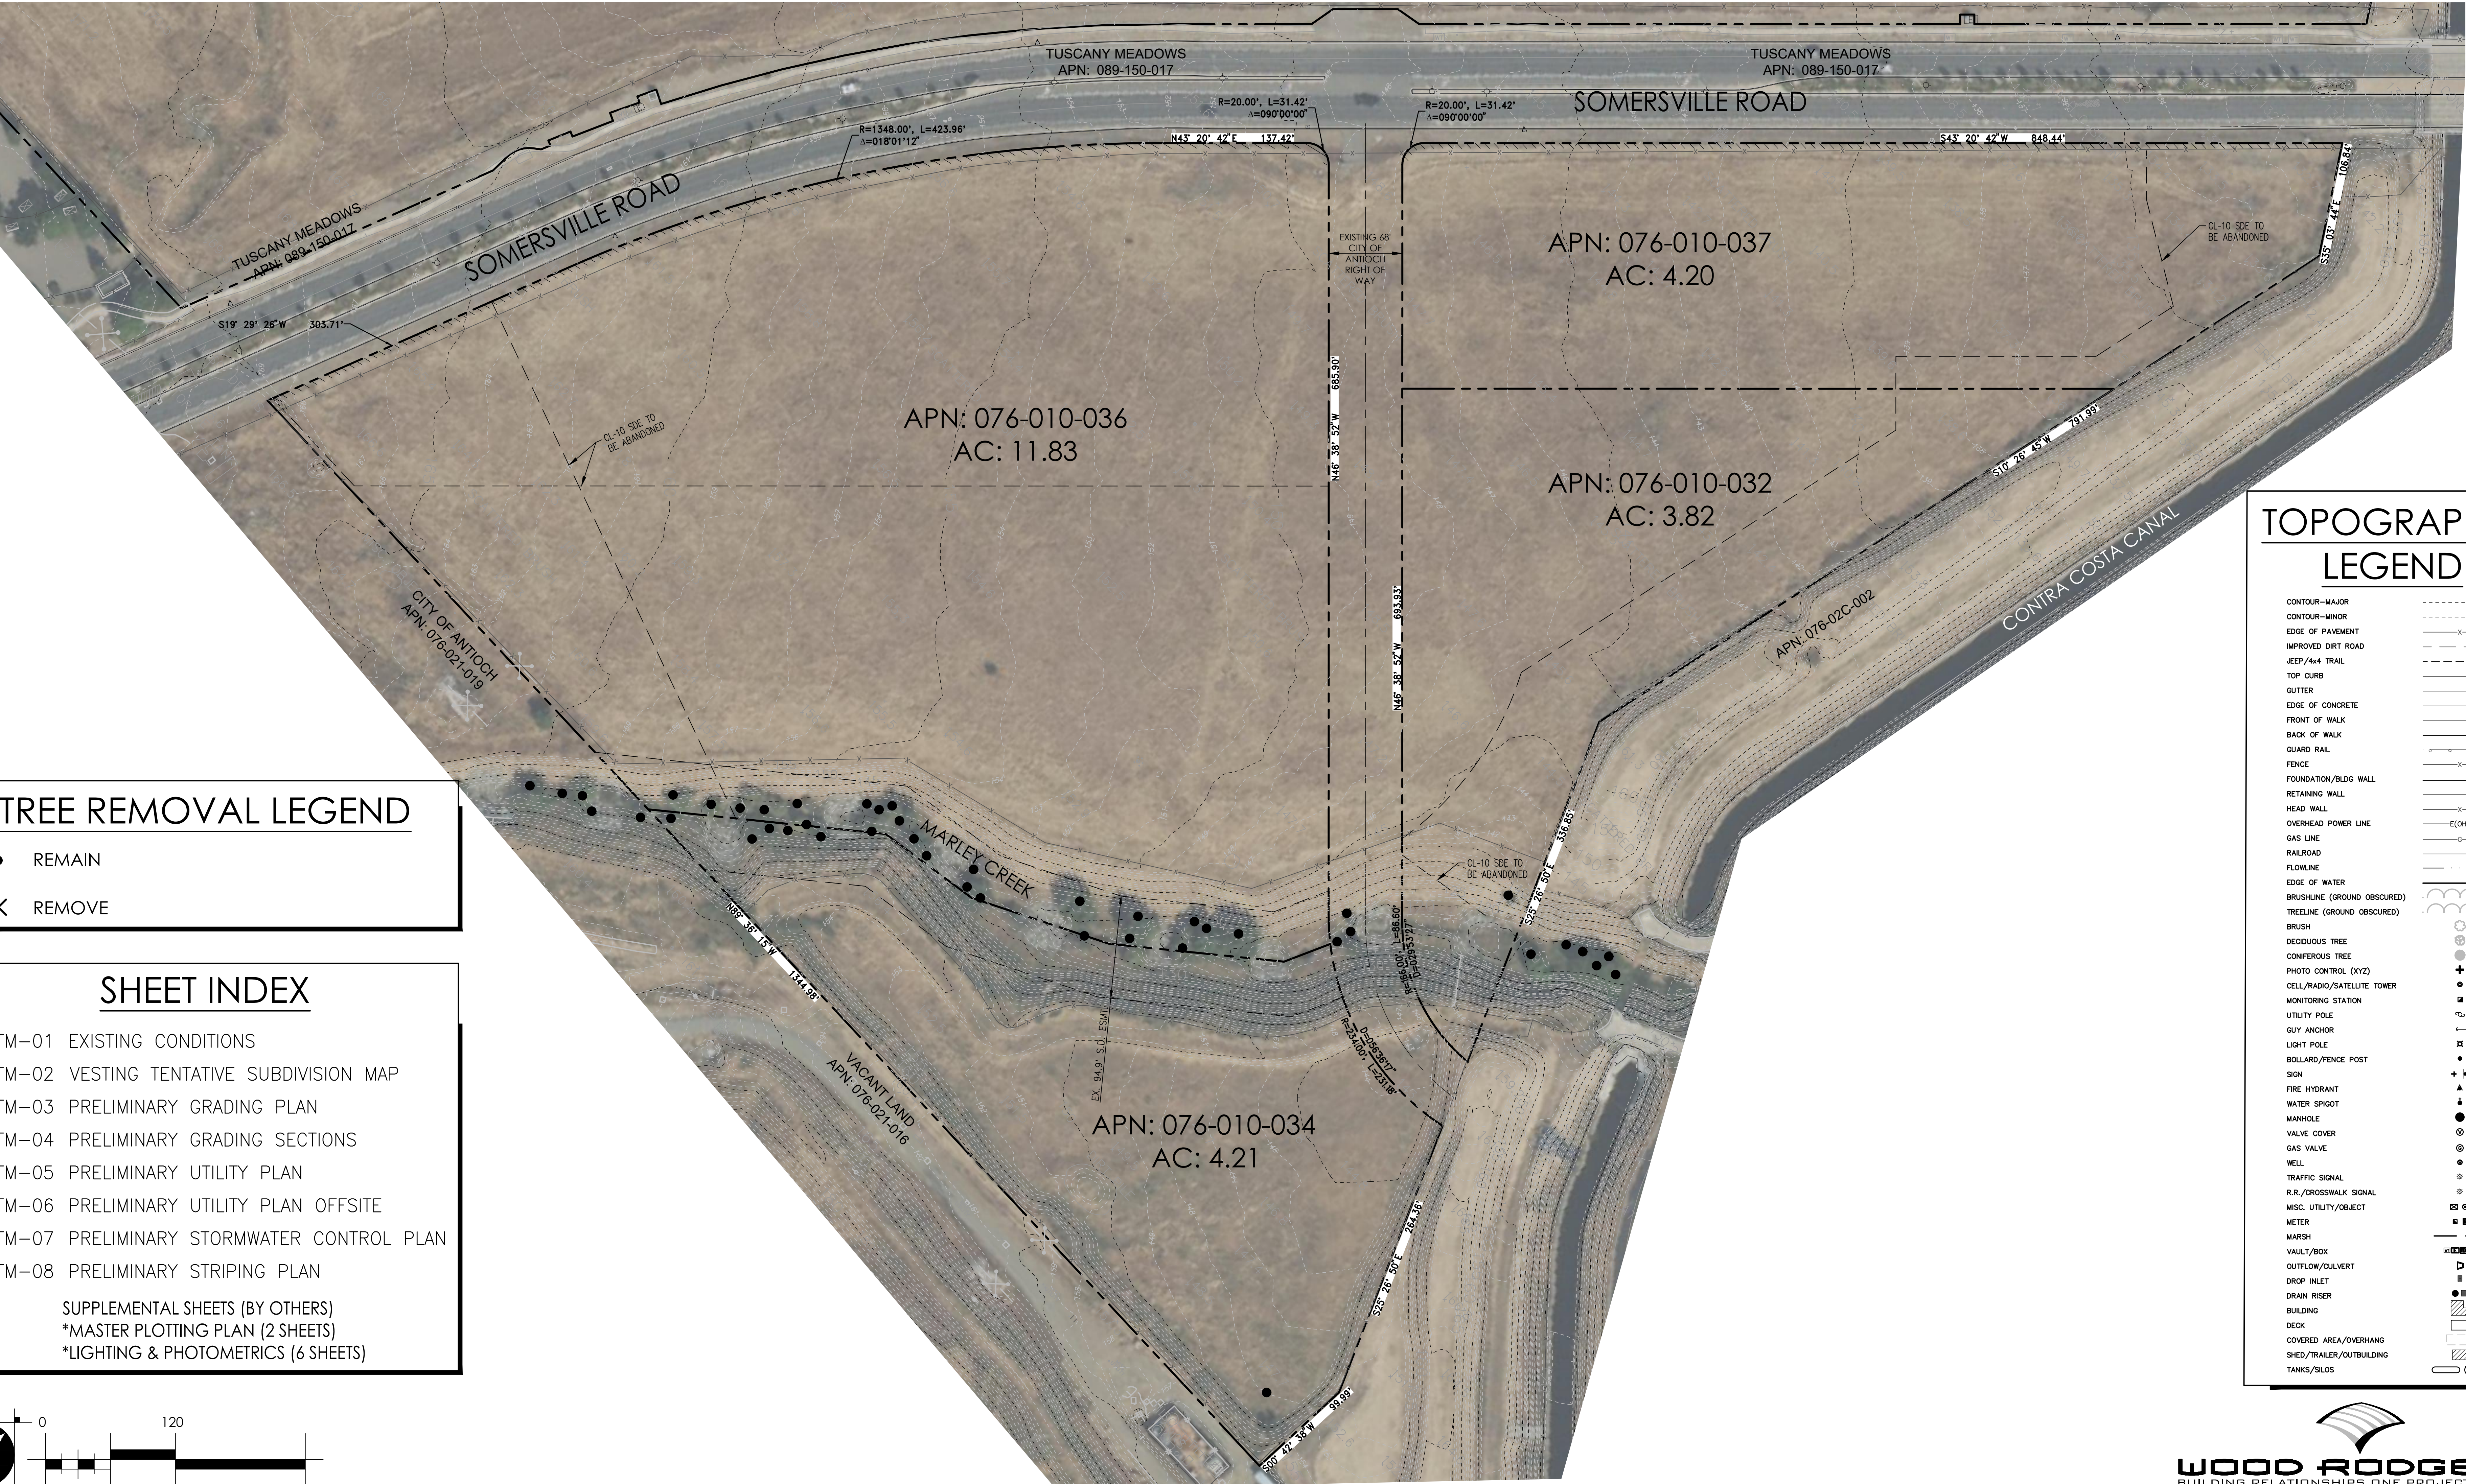


EXISTING CONDITIONS

RIALTO PLACE

CITY OF ANTIOCH, CALIFORNIA
DECEMBER 6 , 2024

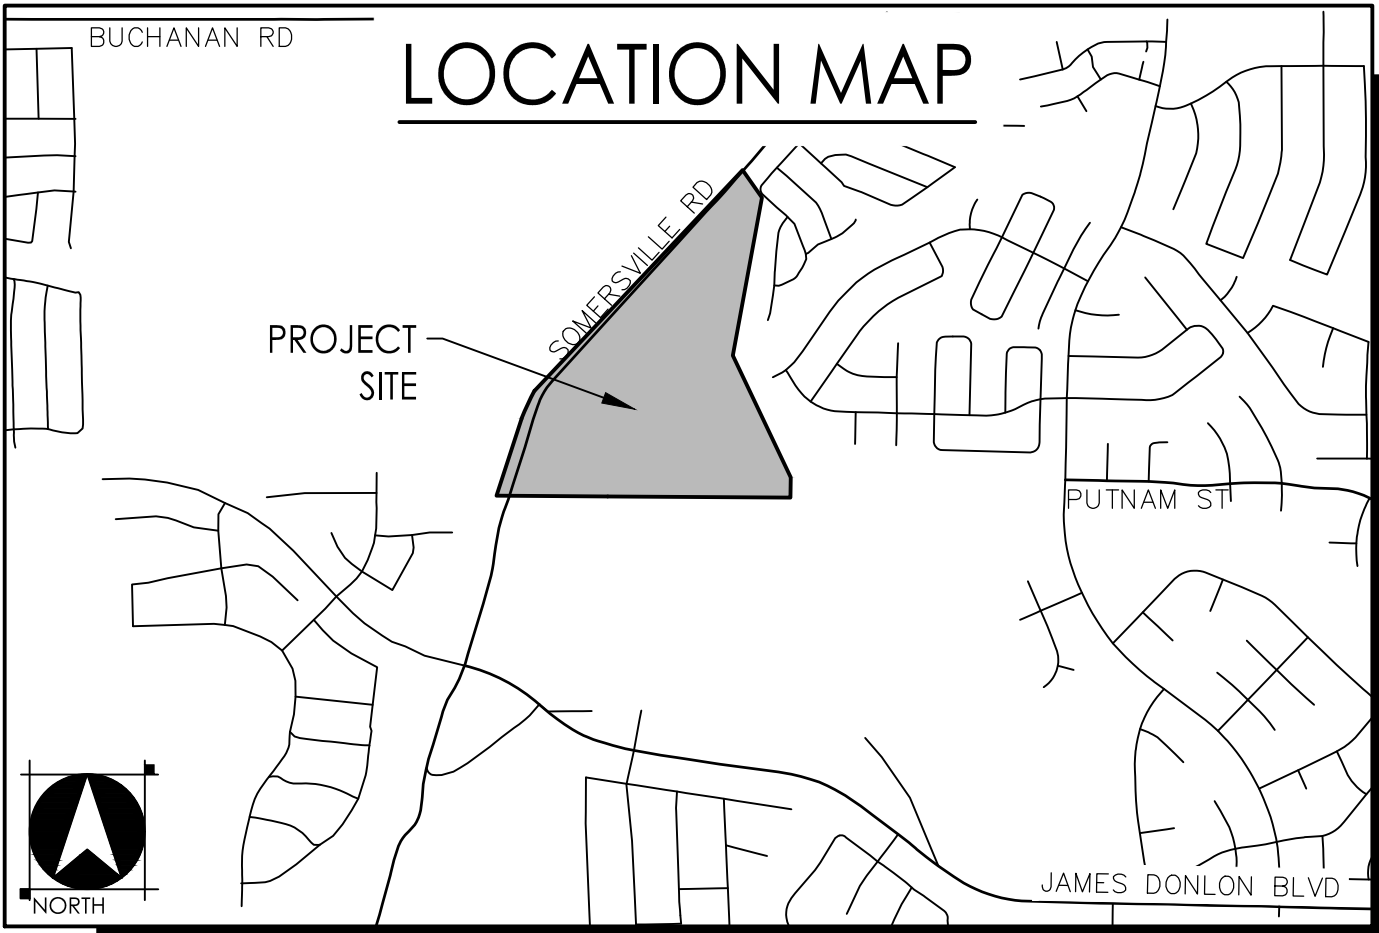

TREE REMOVAL LEGEND


- REMAIN
- ✕ REMOVE

SHEET INDEX

- TM-01 EXISTING CONDITIONS
 - TM-02 VESTING TENTATIVE SUBDIVISION MAP
 - TM-03 PRELIMINARY GRADING PLAN
 - TM-04 PRELIMINARY GRADING SECTIONS
 - TM-05 PRELIMINARY UTILITY PLAN
 - TM-06 PRELIMINARY UTILITY PLAN OFFSITE
 - TM-07 PRELIMINARY STORMWATER CONTROL PLAN
 - TM-08 PRELIMINARY STRIPING PLAN
- SUPPLEMENTAL SHEETS (BY OTHERS)
*MASTER PLOTTING PLAN (2 SHEETS)
*LIGHTING & PHOTOMETRICS (6 SHEETS)

TOPOGRAPHIC LEGEND




- CONTOUR-MAJOR
- CONTOUR-MINOR
- EDGE OF PAVEMENT
- IMPROVED DIRT ROAD
- JEEP/4x4 TRAIL
- TOP CURB
- GUTTER
- EDGE OF CONCRETE
- FRONT OF WALK
- BACK OF WALK
- GUARD RAIL
- FENCE
- FOUNDATION/BLDG WALL
- RETAINING WALL
- HEAD WALL
- OVERHEAD POWER LINE
- GAS LINE
- RAILROAD
- FLOWLINE
- EDGE OF WATER
- BRUSHLINE (GROUND OBSCURED)
- TREELINE (GROUND OBSCURED)
- BRUSH
- DECIDUOUS TREE
- CONIFEROUS TREE
- PHOTO CONTROL (XYZ)
- CELL/RADIO/SATELLITE TOWER
- MONITORING STATION
- UTILITY POLE
- GUY ANCHOR
- LIGHT POLE
- BOLLARD/FENCE POST
- SIGN
- FIRE HYDRANT
- WATER SPIGOT
- MANHOLE
- VALVE COVER
- GAS VALVE
- WELL
- TRAFFIC SIGNAL
- R.R./CROSSWALK SIGNAL
- MISC. UTILITY/OBJECT
- METER
- MARSH
- VAULT/BOX
- OUTFLOW/CULVERT
- DROP INLET
- DRAIN RISER
- BUILDING
- DECK
- COVERED AREA/OVERHANG
- SHED/TRAILER/OUTBUILDING
- TANKS/SILOS

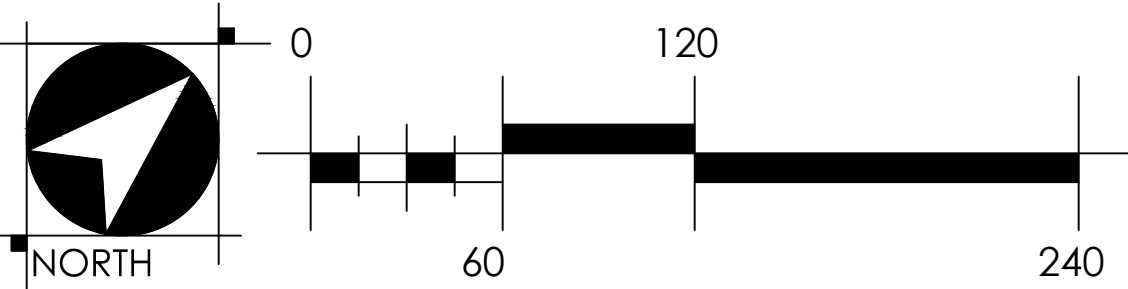

VESTING TENTATIVE SUBDIVISION MAP TRACT-09681

RIALTO PLACE

CITY OF ANTIOCH, CALIFORNIA
DECEMBER 6, 2024

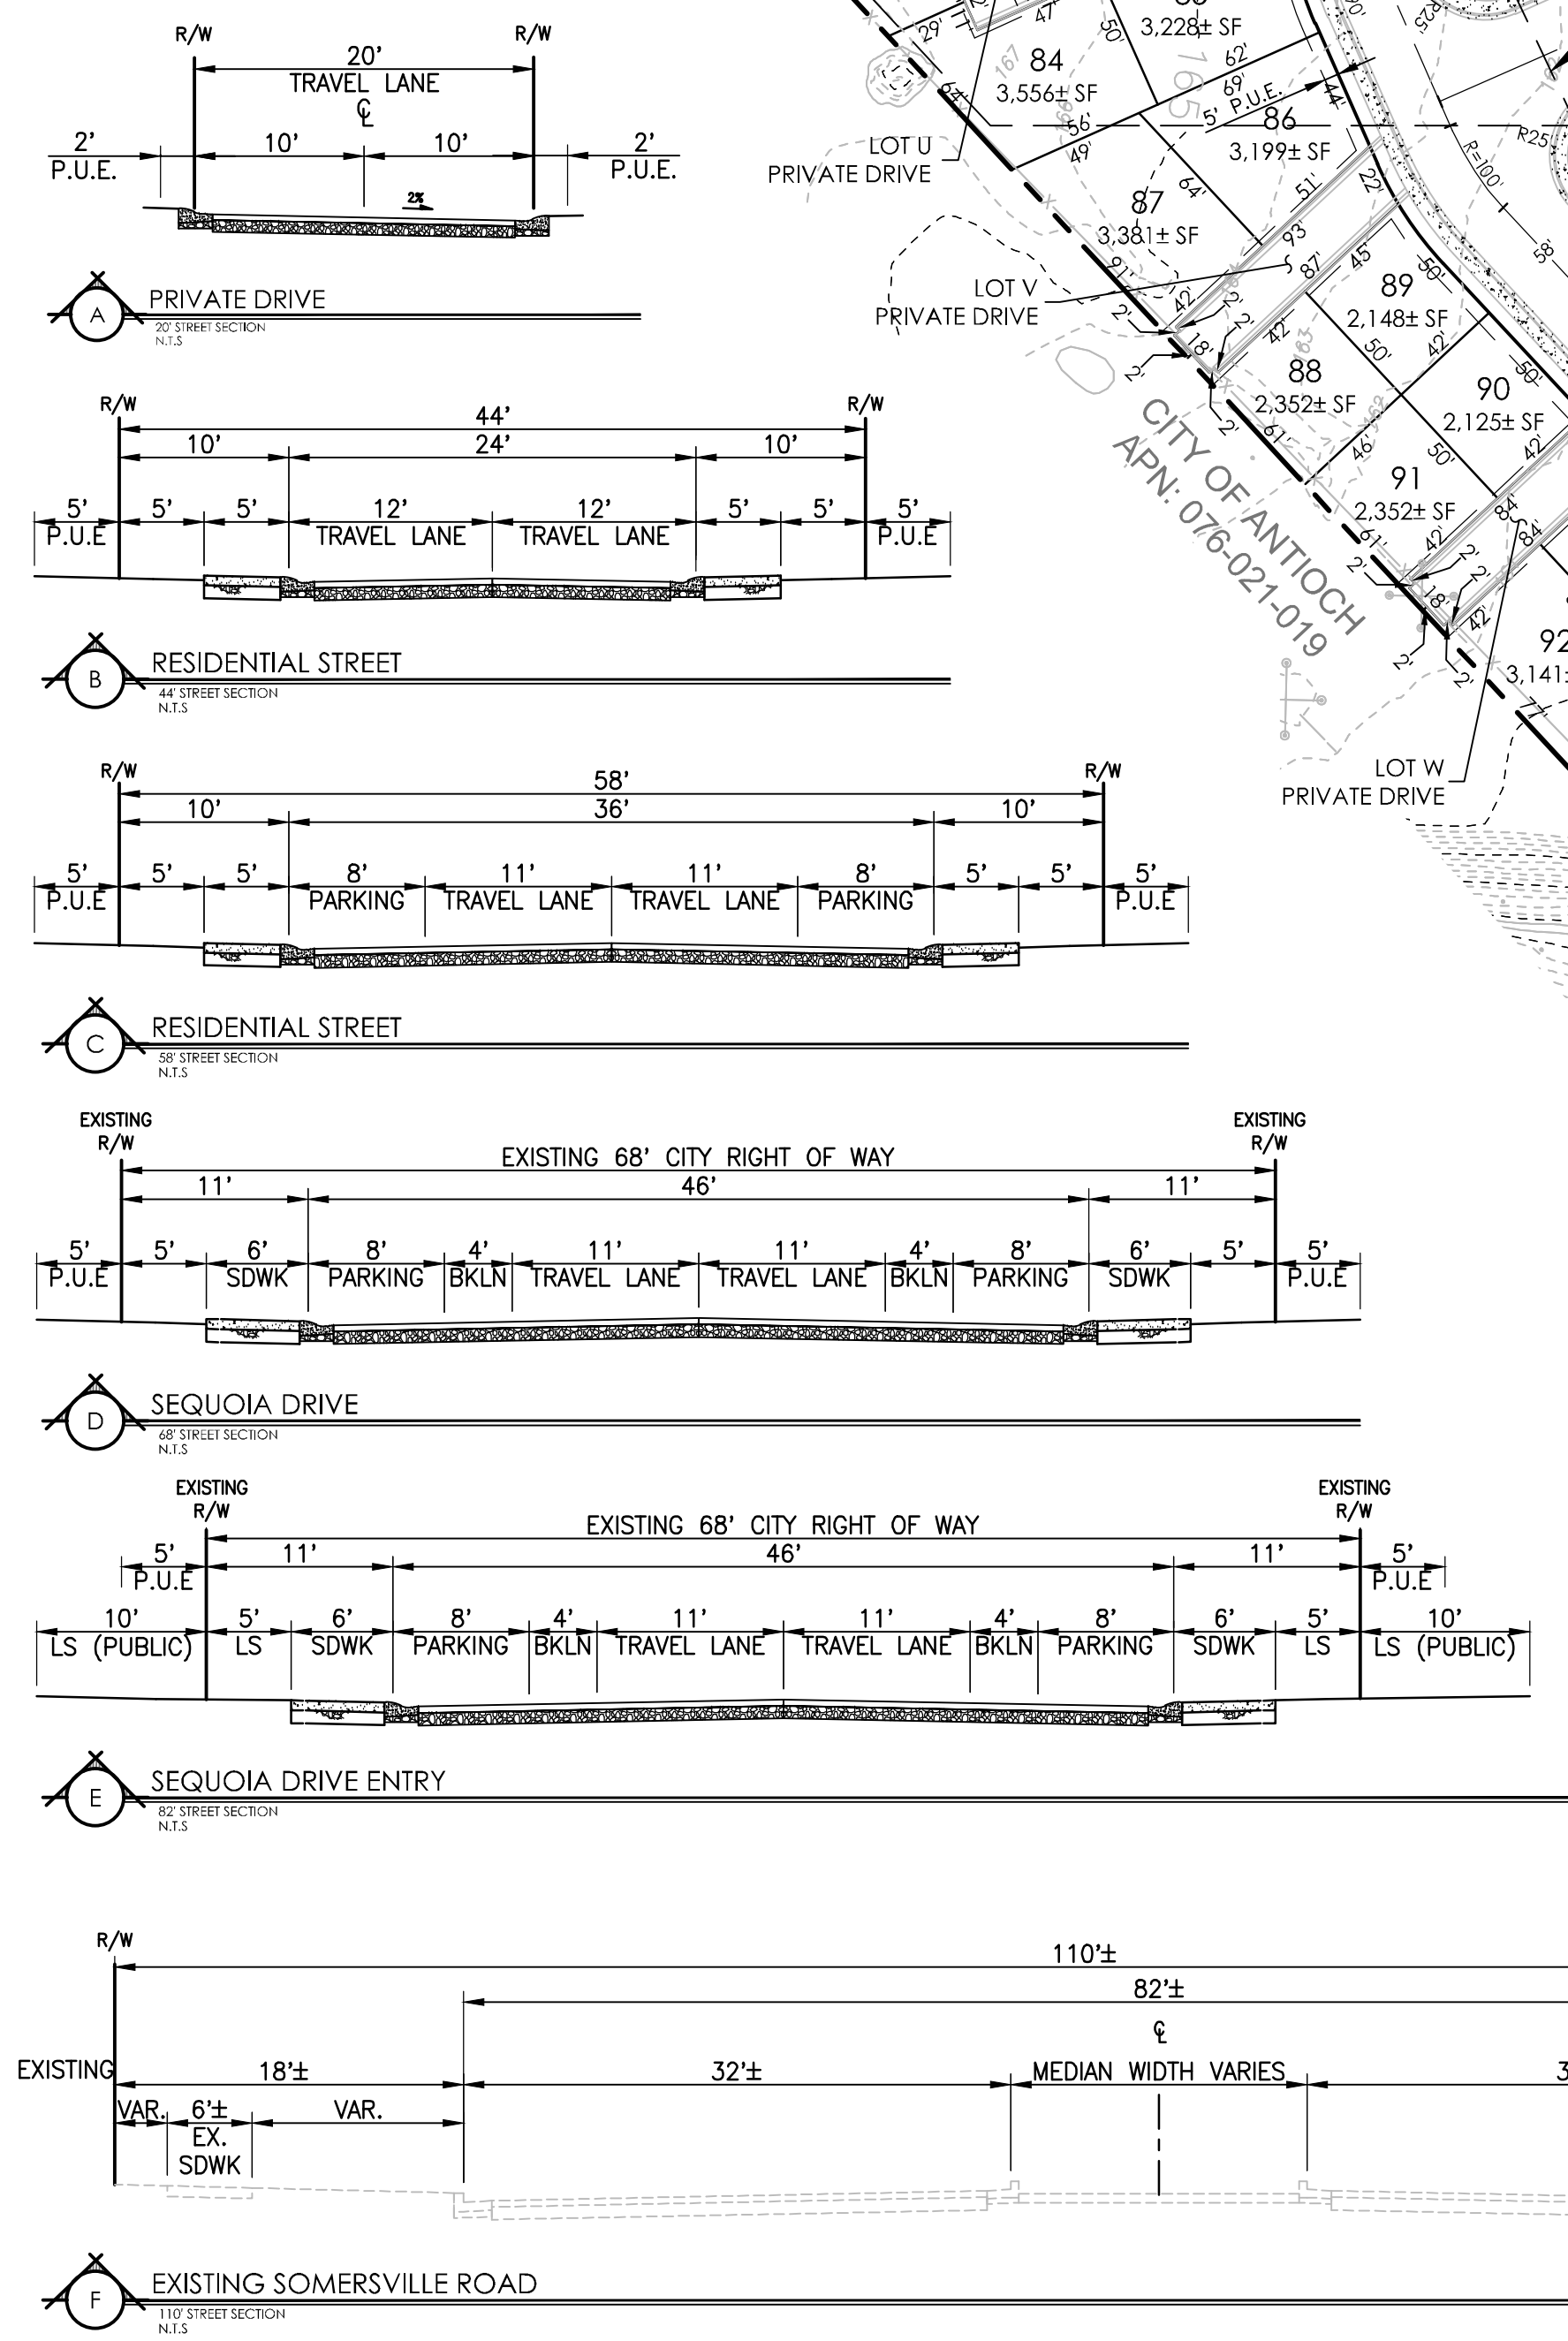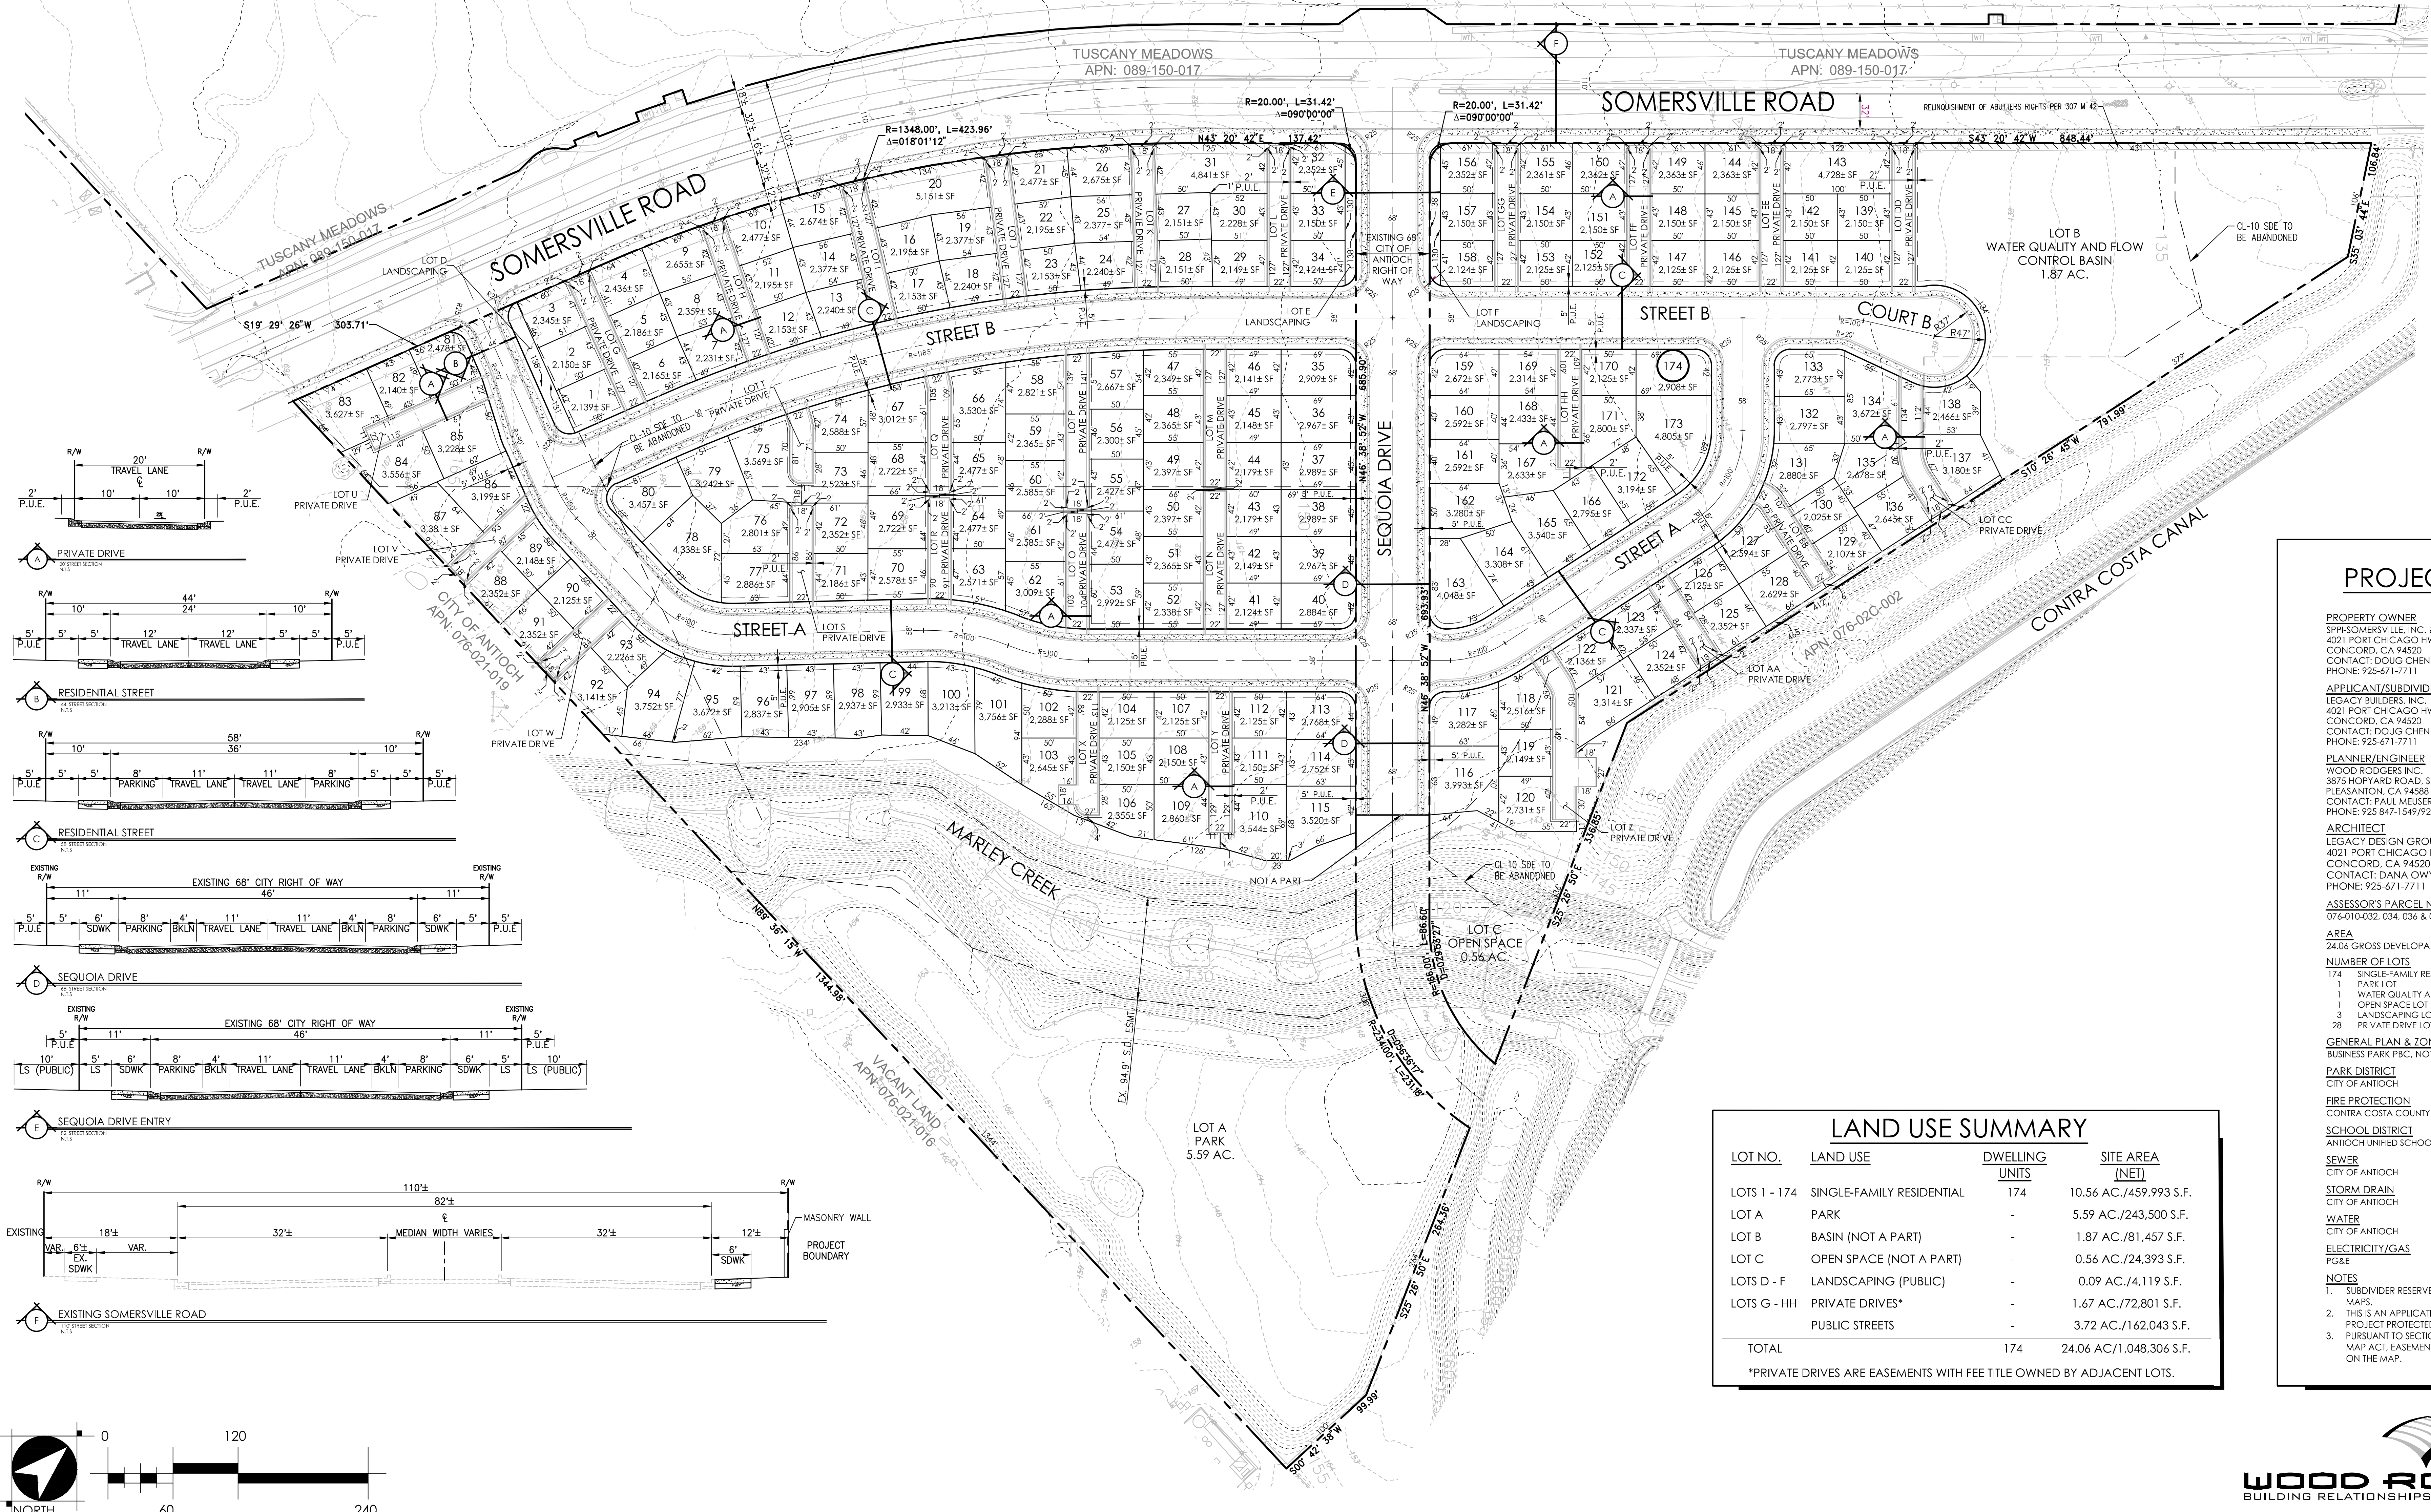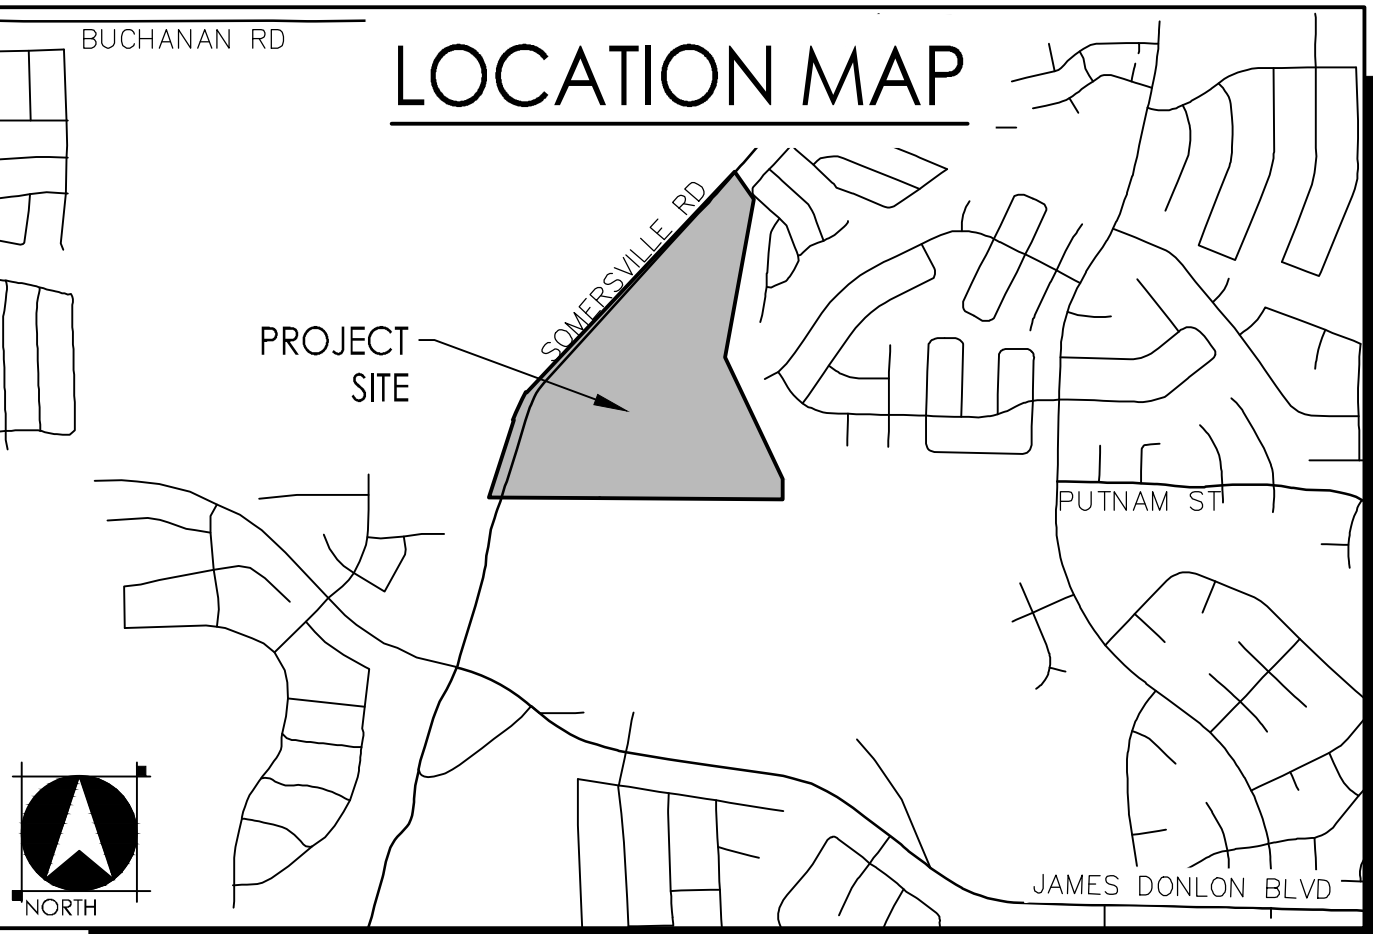

LAND USE SUMMARY			
LOT NO.	LAND USE	DWELLING UNITS	SITE AREA (NET)
LOTS 1 - 174	SINGLE-FAMILY RESIDENTIAL	174	10.56 AC./459,993 S.F.
LOT A	PARK	-	5.59 AC./243,500 S.F.
LOT B	BASIN (NOT A PART)	-	1.87 AC./81,457 S.F.
LOT C	OPEN SPACE (NOT A PART)	-	0.56 AC./24,393 S.F.
LOTS D - F	LANDSCAPING (PUBLIC)	-	0.09 AC./4,119 S.F.
LOTS G - HH	PRIVATE DRIVES*	-	1.67 AC./72,801 S.F.
	PUBLIC STREETS	-	3.72 AC./162,043 S.F.
TOTAL		174	24.06 AC./1,048,306 S.F.

*PRIVATE DRIVES ARE EASEMENTS WITH FEE TITLE OWNED BY ADJACENT LOTS.

PROJECT NOTES

PROPERTY OWNER
SPFL-SOMERSVILLE, INC. & SOMERSVILLE-GENTRY, INC.
4021 PORT CHICAGO HWY.
CONCORD, CA 94520
CONTACT: DOUG CHEN
PHONE: 925-671-7711

APPLICANT/SUBDIVIDER
LEGACY BUILDERS, INC.
4021 PORT CHICAGO HWY.
CONCORD, CA 94520
CONTACT: DOUG CHEN
PHONE: 925-671-7711

PLANNER/ENGINEER
WOOD RODGERS INC.
3875 HOPKINS ROAD, SUITE 345
PLEASANTON, CA 94588
CONTACT: PAUL MEUSER/ KARRIE MOSCA
PHONE: 925-847-1549/925-847-1547

ARCHITECT
LEGACY DESIGN GROUP
4021 PORT CHICAGO HWY.
CONCORD, CA 94520
CONTACT: DANA OWYOUNG
PHONE: 925-671-7711

ASSESSOR'S PARCEL NO.
076-010-032, 034, 036 & 037

AREA
24.06 GROSS DEVELOPABLE ACRES / 1,048,306 S.F.

NUMBER OF LOTS
174
1 PARK LOT
1 WATER QUALITY AND FLOW CONTROL BASIN
1 OPEN SPACE LOT
3 LANDSCAPING LOTS
28 PRIVATE DRIVE LOTS

GENERAL PLAN & ZONING EXISTING
BUSINESS PARK PBC, NOT APPLICABLE DUE TO 58330

PARK DISTRICT
CITY OF ANTIOCH

FIRE PROTECTION
CONTRA COSTA COUNTY FIRE PROTECTION DISTRICT

SCHOOL DISTRICT
ANTIOCH UNIFIED SCHOOL DISTRICT


SEWER
CITY OF ANTIOCH

STORM DRAIN
CITY OF ANTIOCH

WATER
CITY OF ANTIOCH

ELECTRICITY/GAS
PG&E

NOTES
1. SUBDIVIDER RESERVES THE RIGHT TO FILE MULTIPLE FINAL MAPS.
2. THIS IS AN APPLICATION FOR A HOUSING DEVELOPMENT PROJECT PROTECTED UNDER HAA/HCA/SDBL.
3. PURSUANT TO SECTION 66434(g) OF THE SUBDIVISION MAP ACT, EASEMENTS TO BE ABANDONED ARE MARKED ON THE MAP.

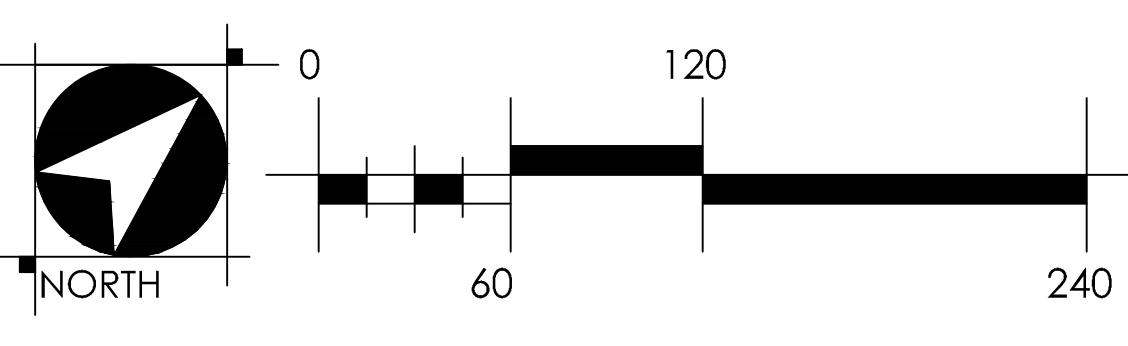

WOOD RODGERS
BUILDING RELATIONSHIPS ONE PROJECT AT A TIME
3875 HOPKINS ROAD STE 345 TEL 925.847.1556
PLEASANTON, CA 94588 FAX 925.847.1557

PRELIMINARY GRADING PLAN

RIALTO PLACE

CITY OF ANTIOCH, CALIFORNIA
DECEMBER 6, 2024




PRELIMINARY GRADING SECTIONS


RIALTO PLACE

CITY OF ANTIOCH, CALIFORNIA

DECEMBER 6 , 2024

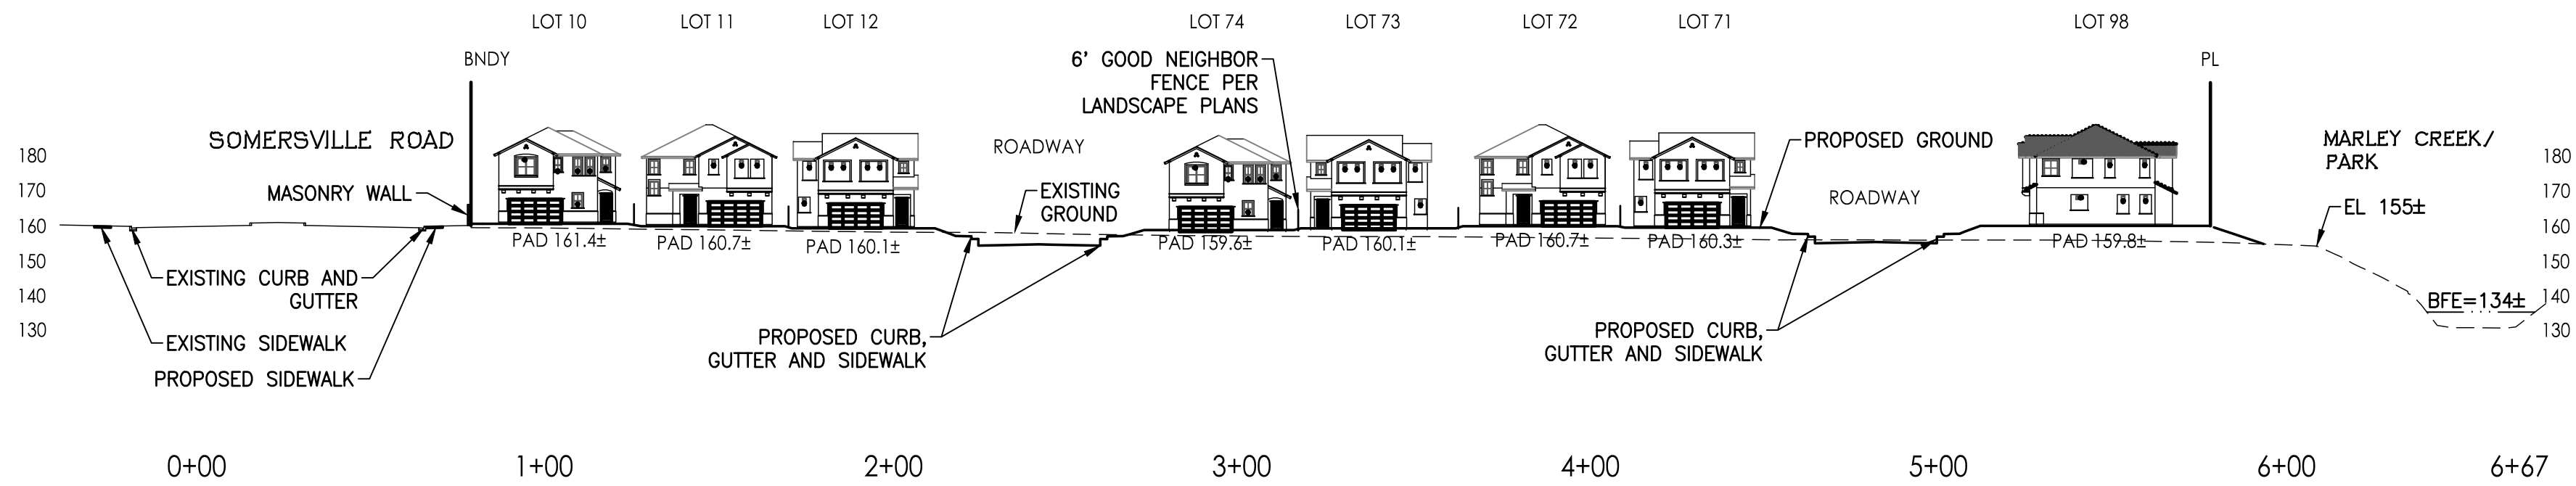

SECTION 1
SCALE: 1"=40'

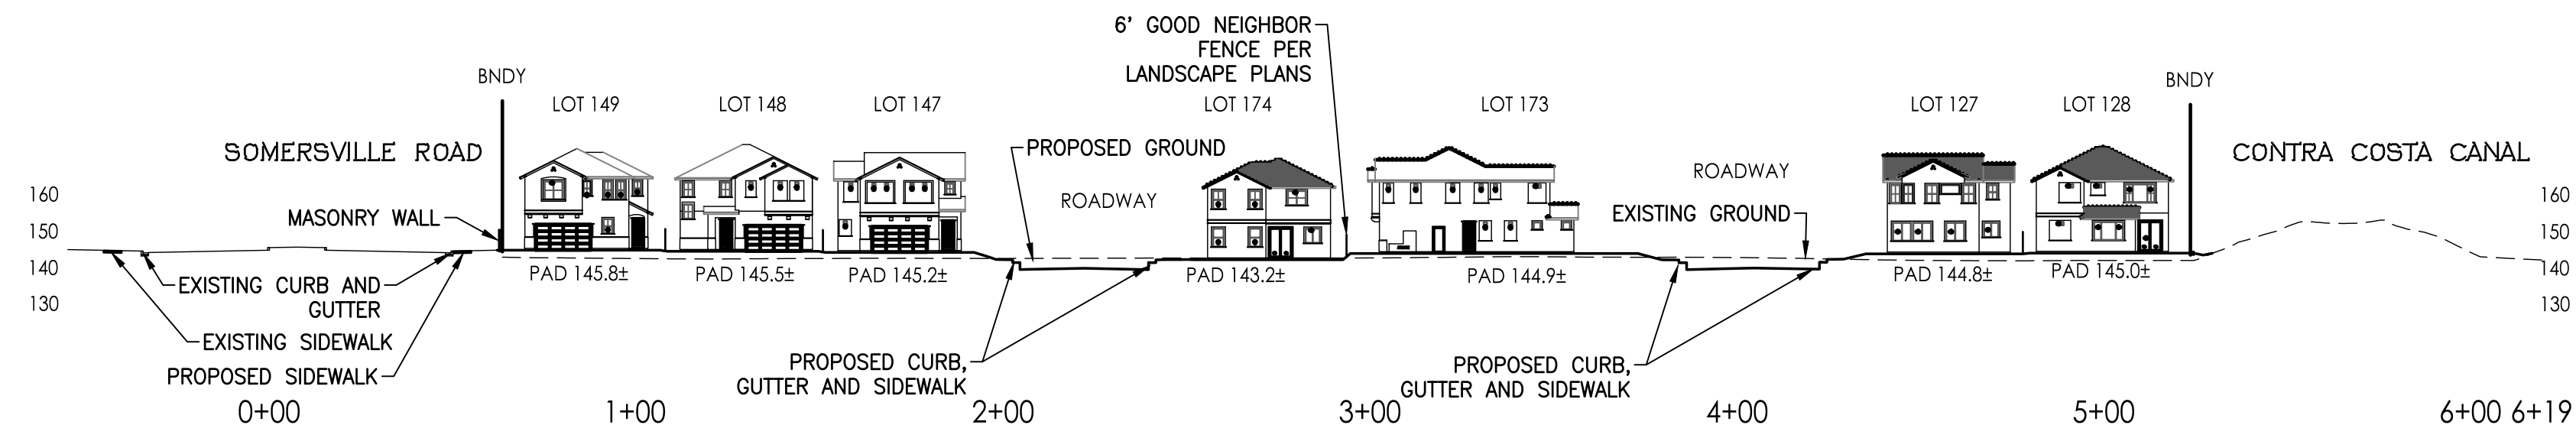

SECTION 2
SCALE: 1"=40'

TRUE CROSS SECTIONS




SECTION A
1"=10'
REQUIRED ENGINEERED CROSS SECTIONS




SECTION B
1"=10'
REQUIRED ENGINEERED CROSS SECTIONS


ENGINEERED CROSS SECTIONS

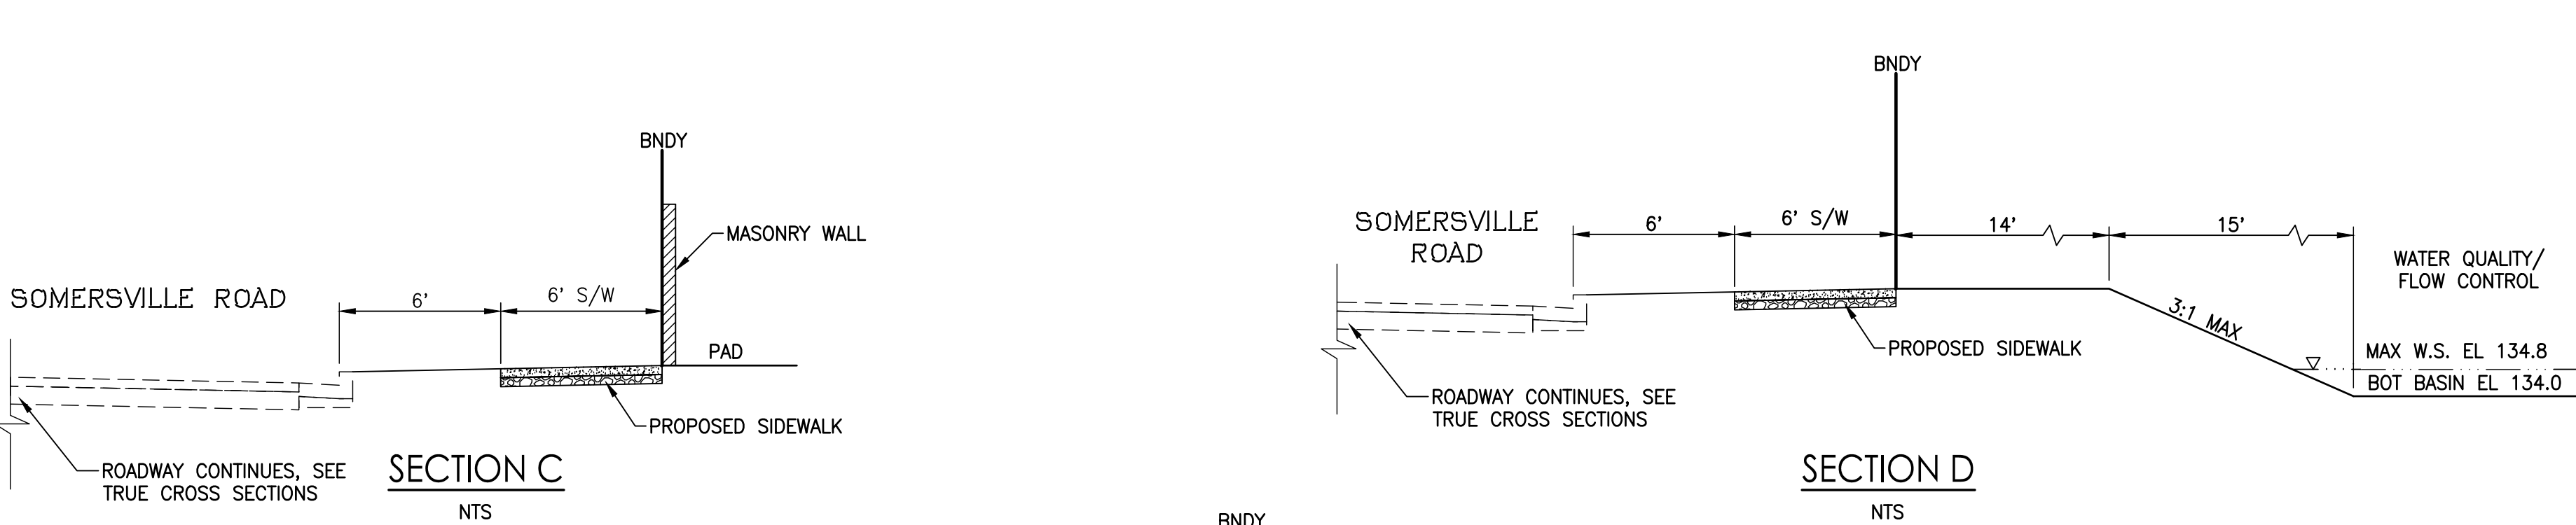


SECTION C
NTS

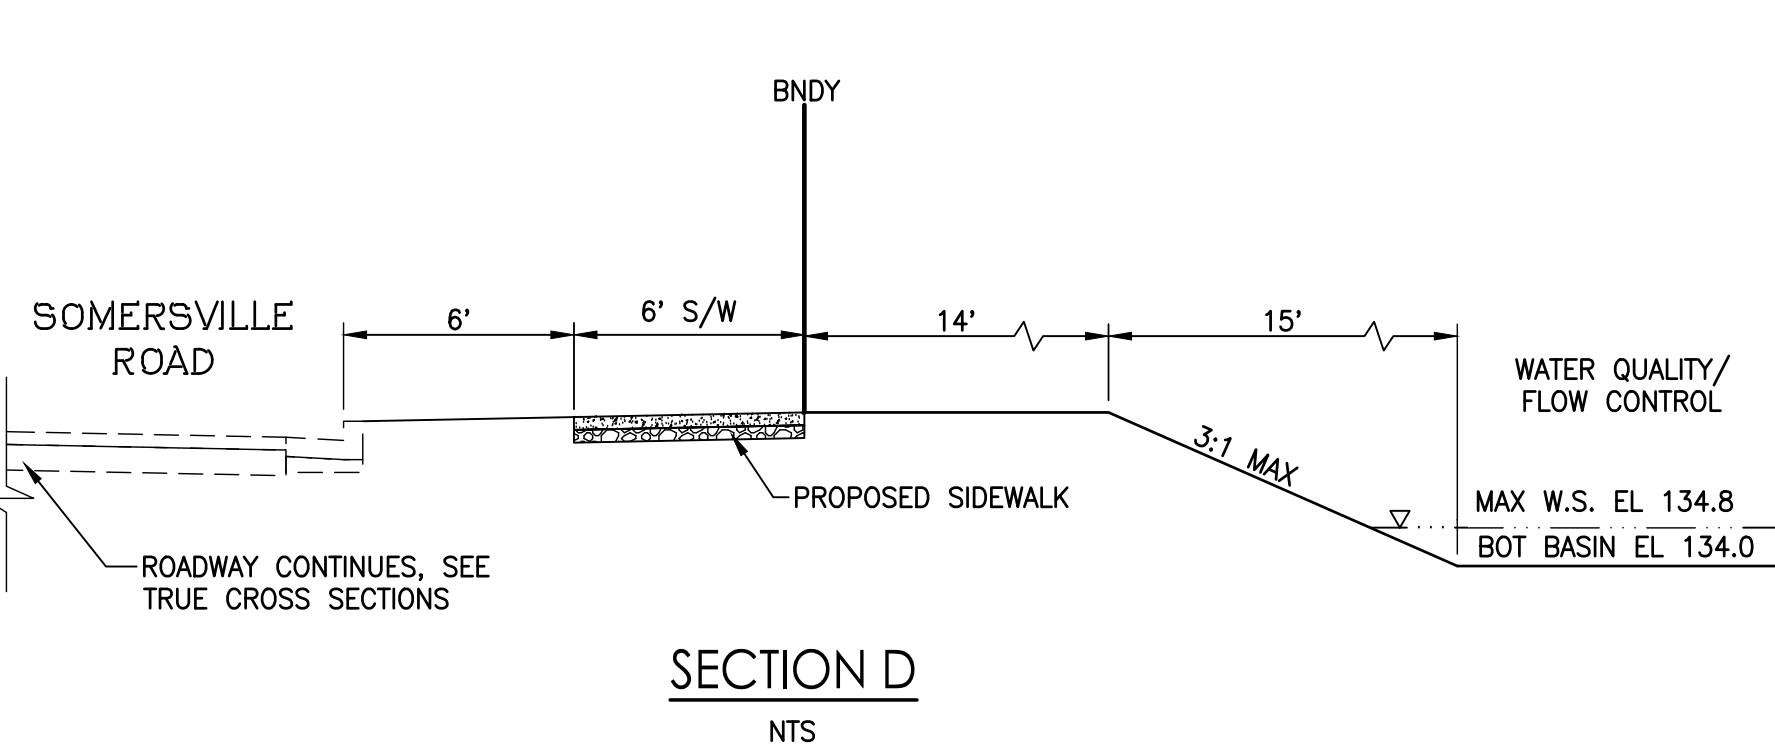


SECTION D
NTS

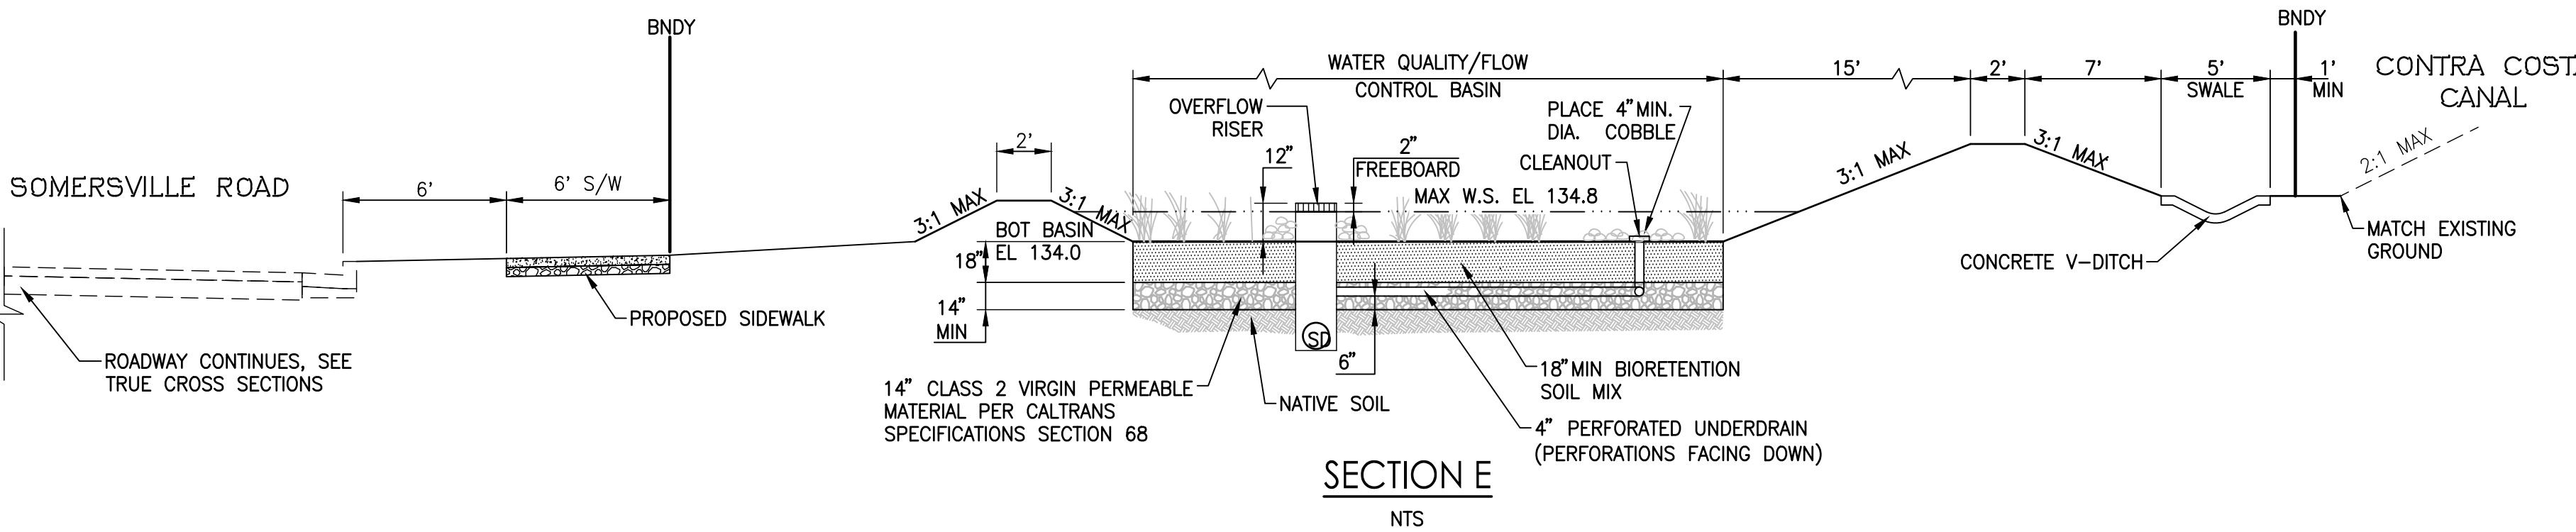


SECTION E
NTS

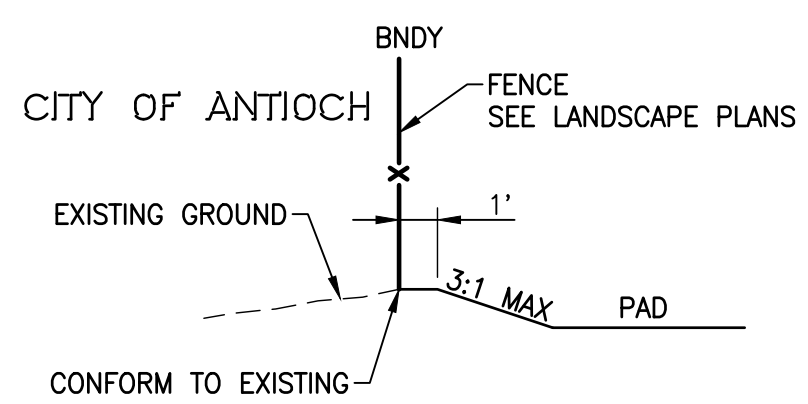


SECTION F
NTS

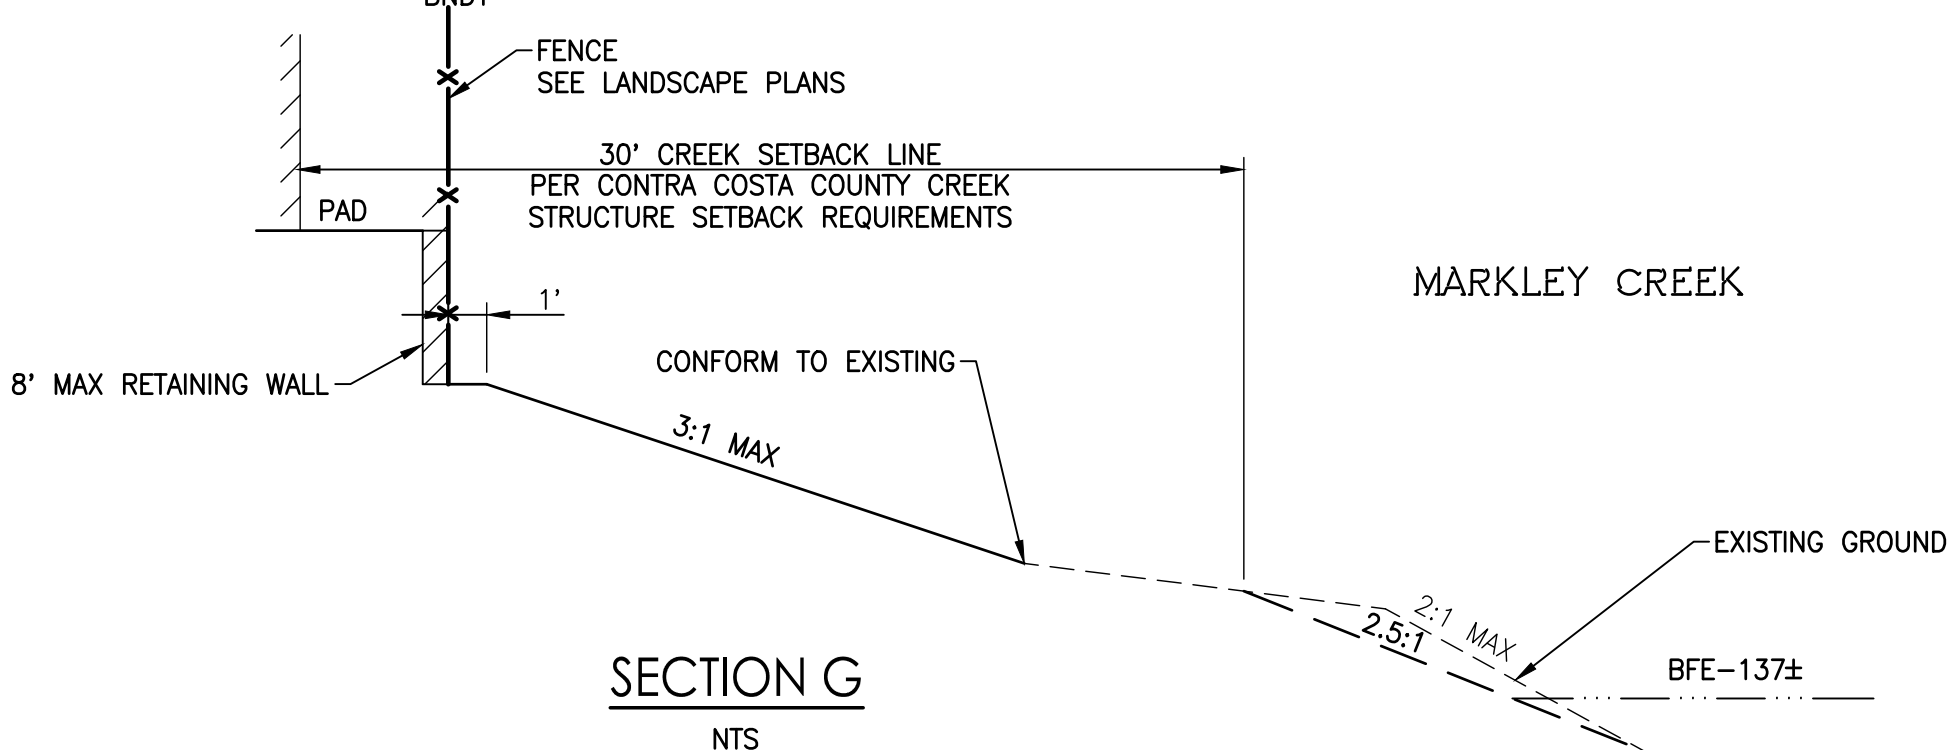

SECTION G
NTS

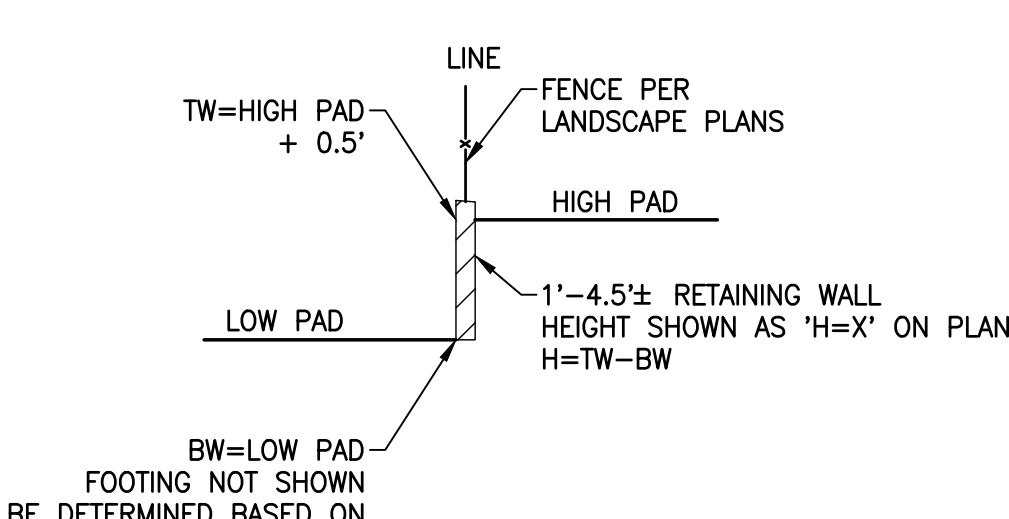

TYPICAL SIDE YARD/
REAR YARD W/RETAINING
NTS

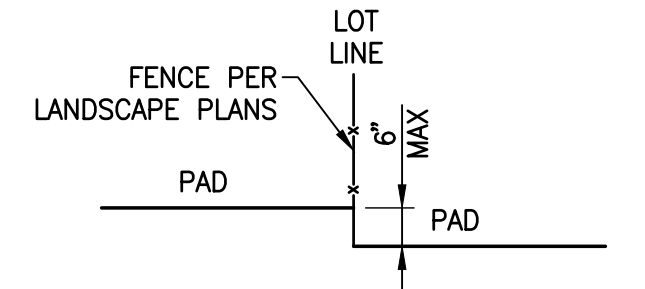

TYPICAL SIDE YARD/ REAR YARD
NTS


ADDITIONAL ENGINEERED CROSS SECTIONS (NOT REQUIRED)

PRELIMINARY UTILITY PLAN

RIALTO PLACE


CITY OF ANTIOCH, CALIFORNIA
DECEMBER 6 , 2024

SEE OFFSITE UTILITY PLAN FOR CONTINUATION

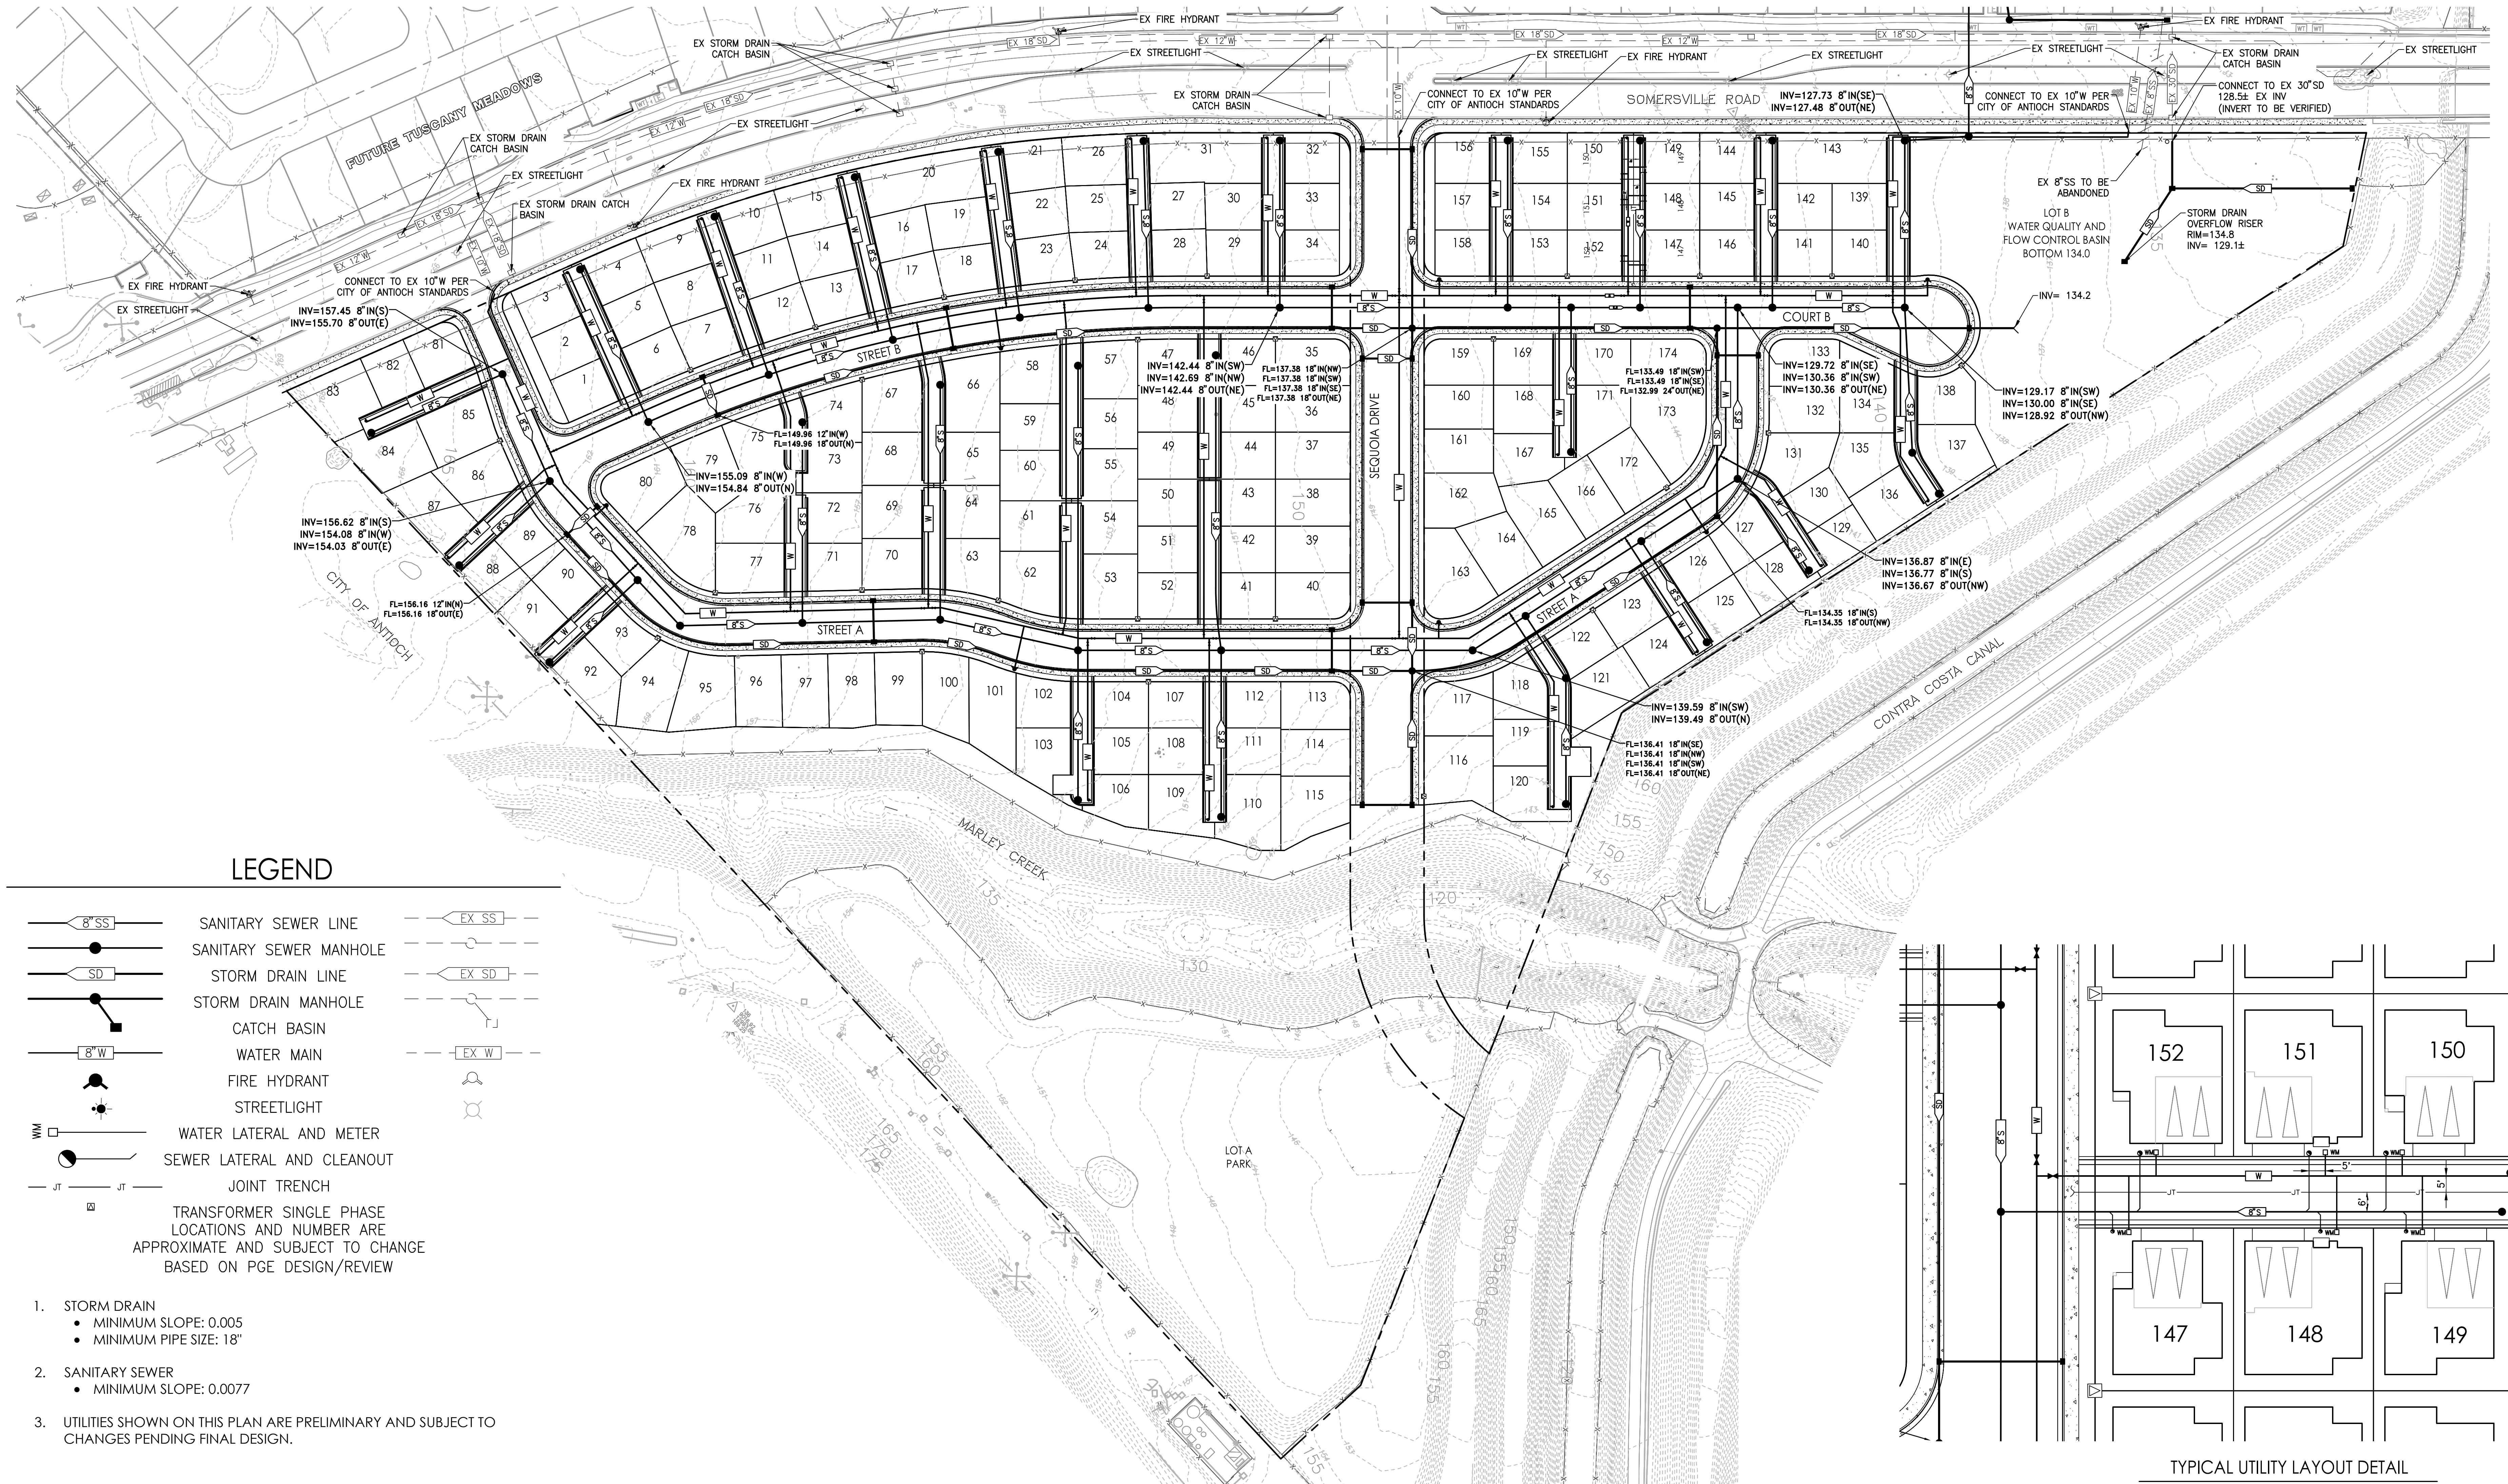

TYPICAL UTILITY LAYOUT DETAIL

1"=20'


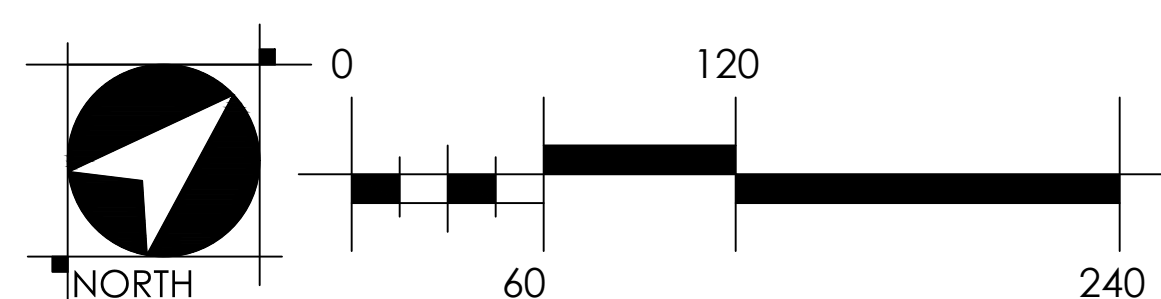


PRELIMINARY UTILITY PLAN OFFSITE

RIALTO PLACE

CITY OF ANTIOCH, CALIFORNIA

DECEMBER 6, 2024

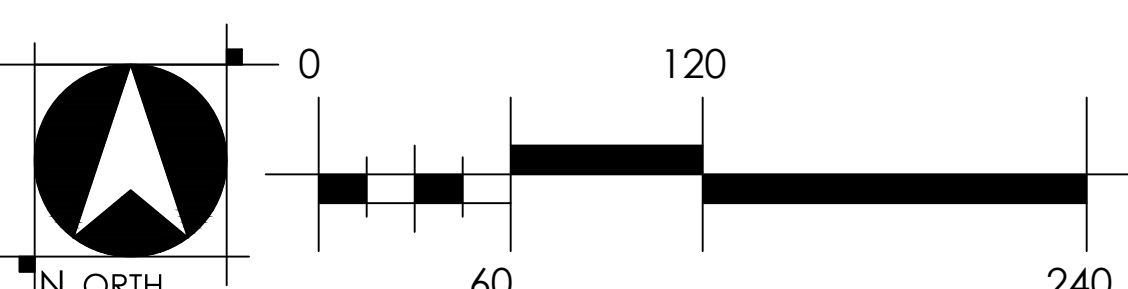
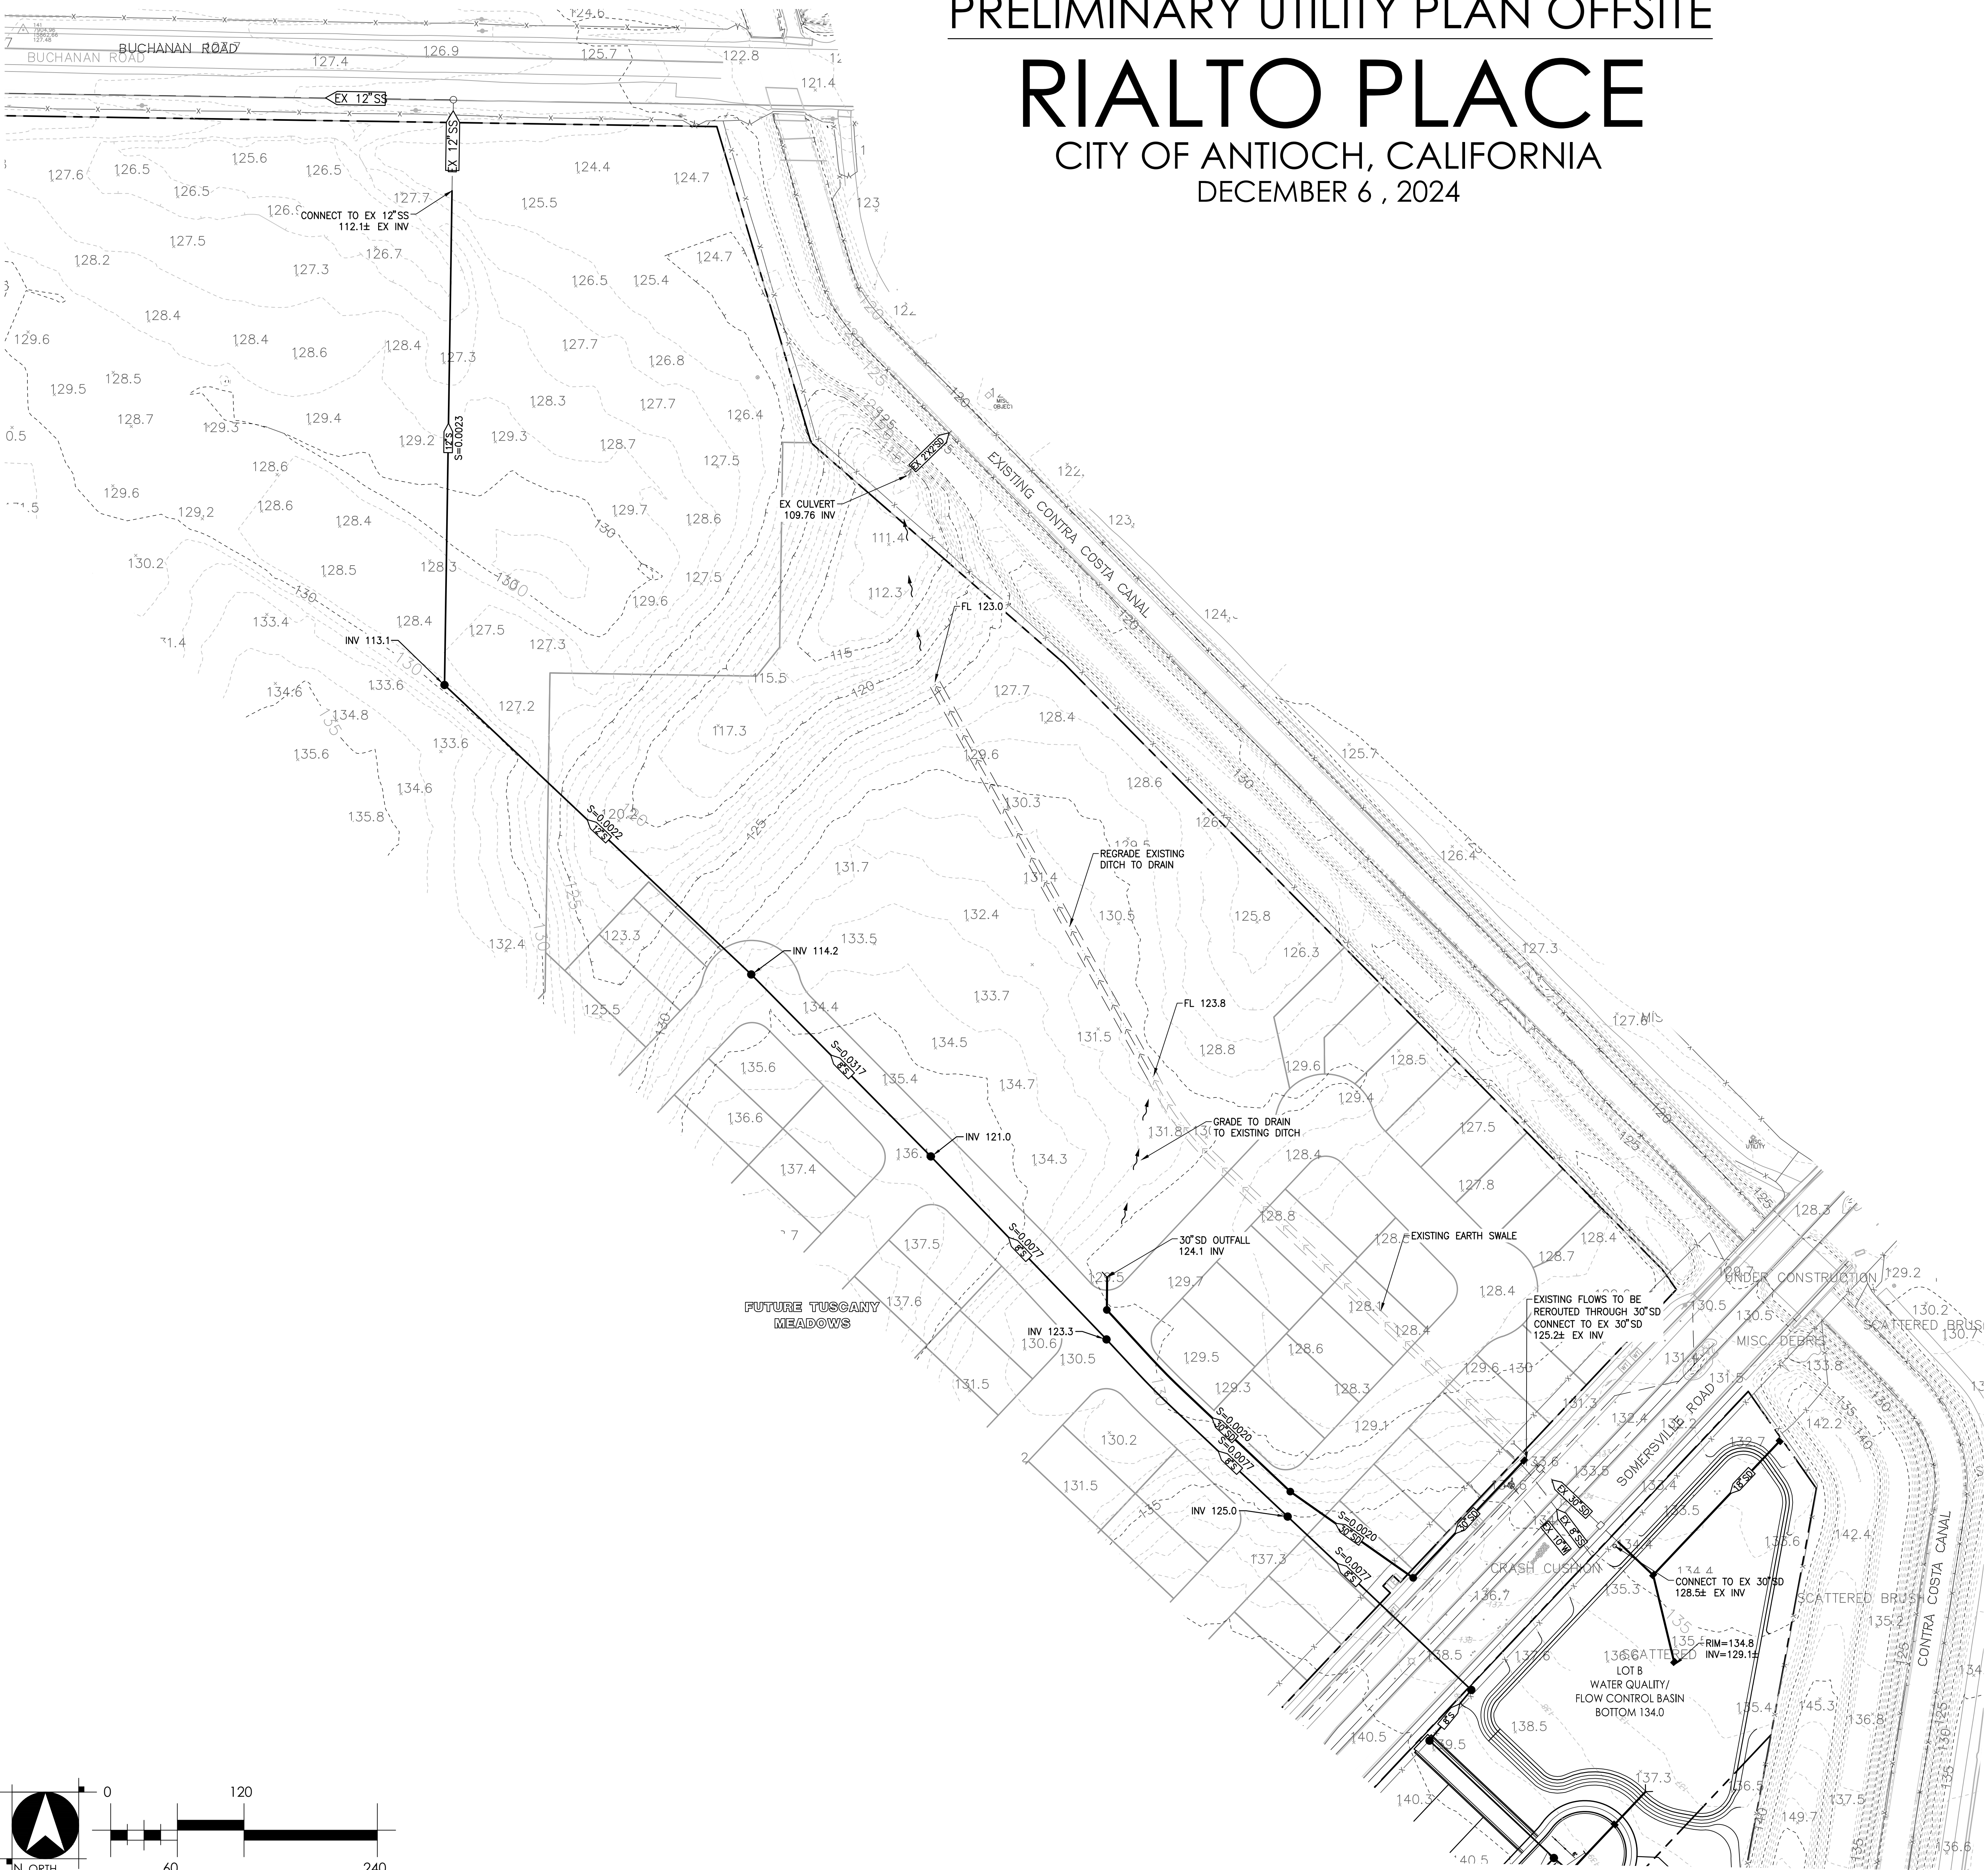


PRELIMINARY STORMWATER CONTROL PLAN

RIALTO PLACE

CITY OF ANTIOCH, CALIFORNIA

DECEMBER 6, 2024

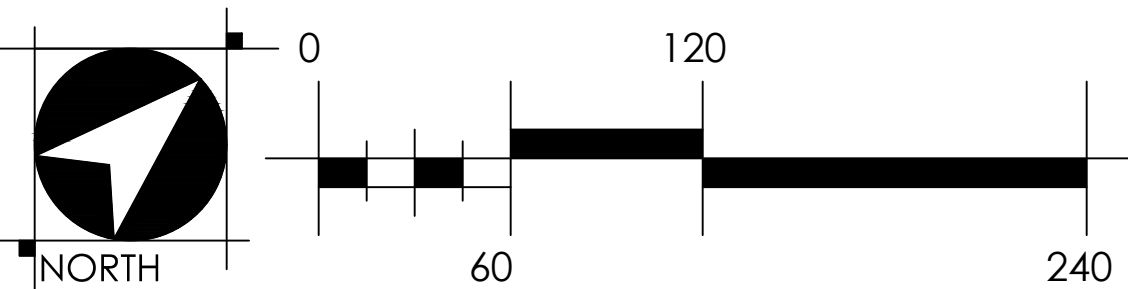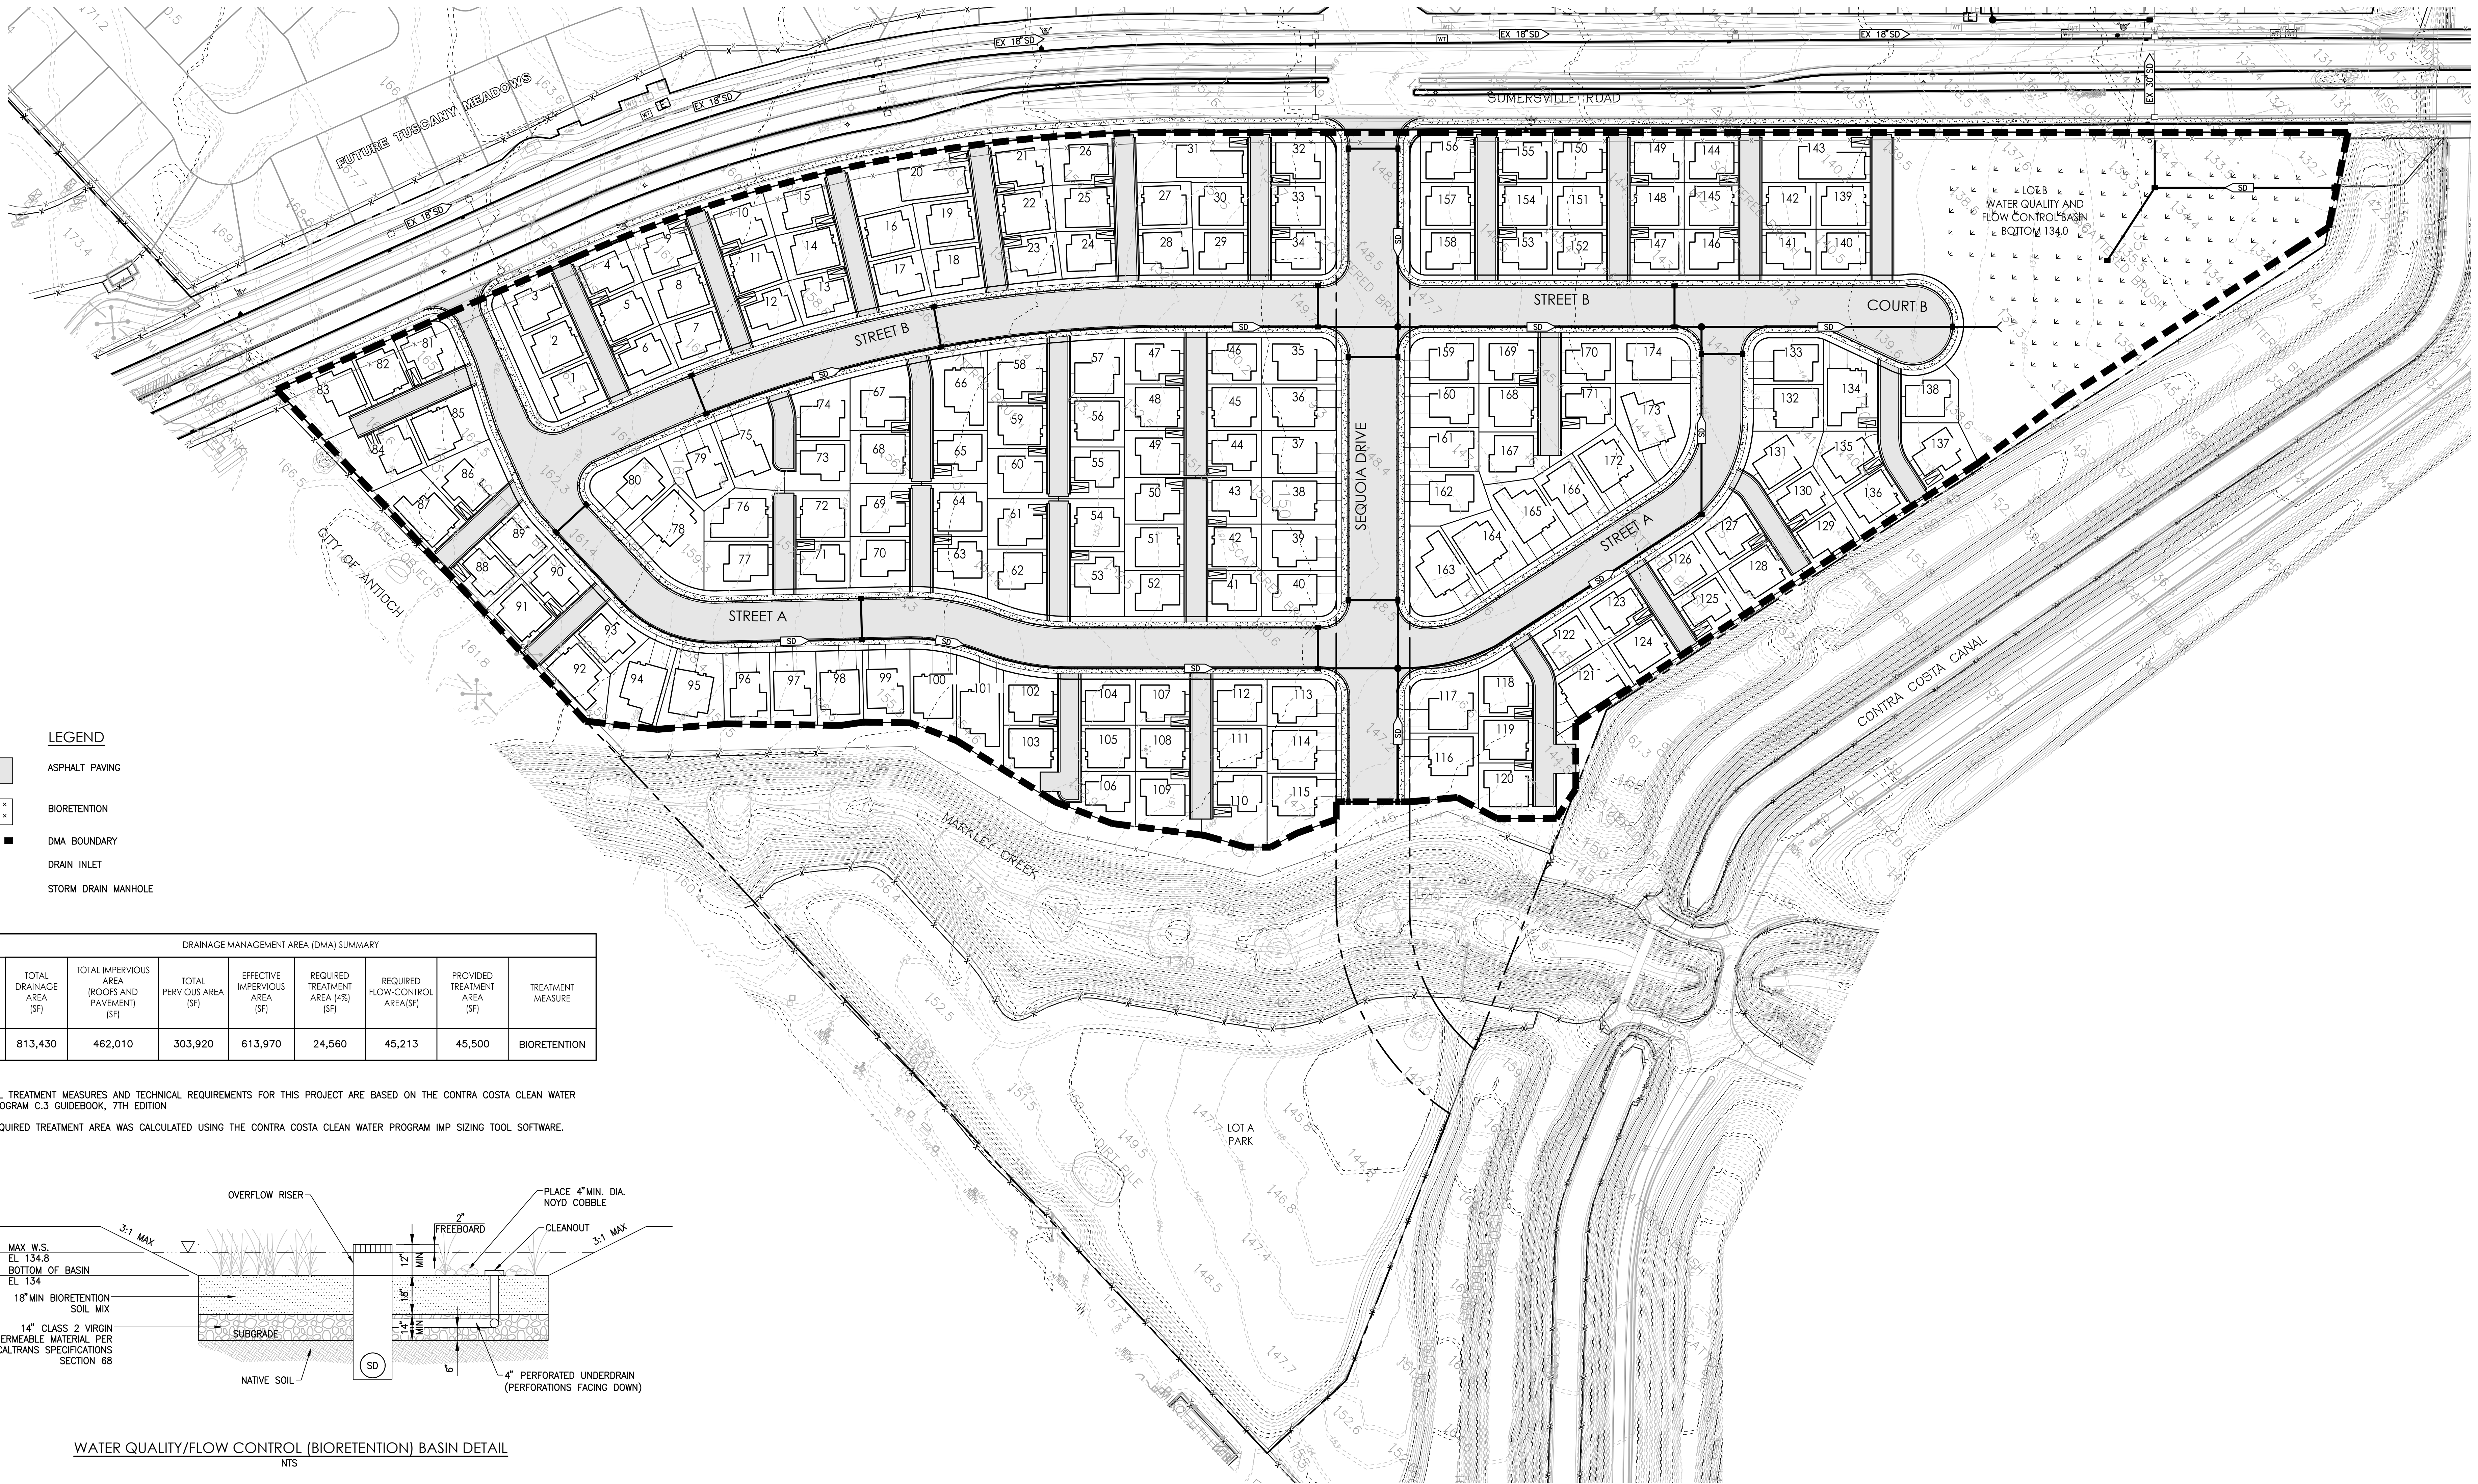

PRELIMINARY STRIPING PLAN

RIALTO PLACE

CITY OF ANTIOCH, CALIFORNIA
DECEMBER 6, 2024




STRIPING AND SIGNING NOTES

- ALL STRIPING, PAVEMENT MARKINGS, AND SIGNS SHALL CONFORM TO THE LATEST EDITION OF THE CALIFORNIA MUTCD AND MOST CURRENT CITY STANDARD DETAILS AND SPECIFICATIONS.
- ALL DETAIL NUMBERS REFER TO CALTRANS STANDARD PLANS STRIPING DETAILS.


LEGEND

- # STREET NAME SIGN (SNS)
- REFLECTIVE "BLUE DOT" FIRE HYDRANT MARKER INSTALLED ADJACENT TO HYDRANT 6' OFF CENTERLINE AS SHOWN.
- STOP SIGN (R1-1)
- SITE TRIANGLE BASED ON CALTRANS STOPPING SITE DISTANCE STANDARDS

THERMOPLASTIC STOP
LEGEND PER CALTRANS STD
A240 CENTERED IN LANE
50' OF DETAIL 22

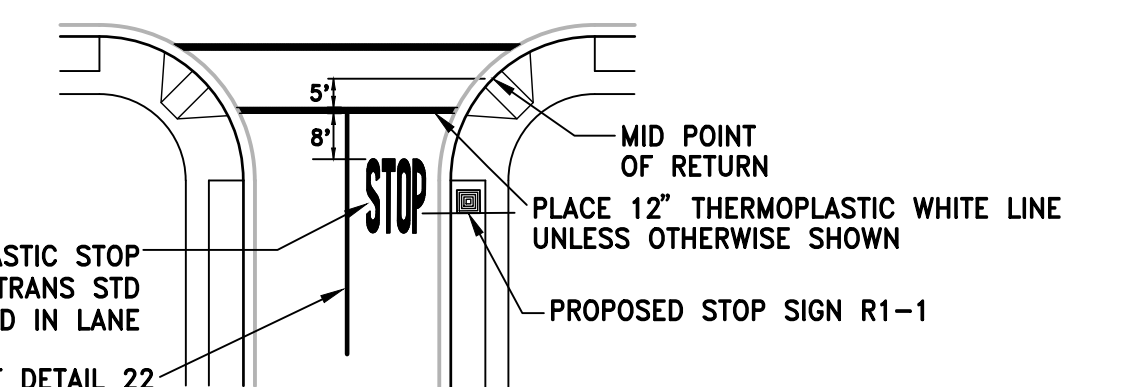

STOP MARKING DETAIL

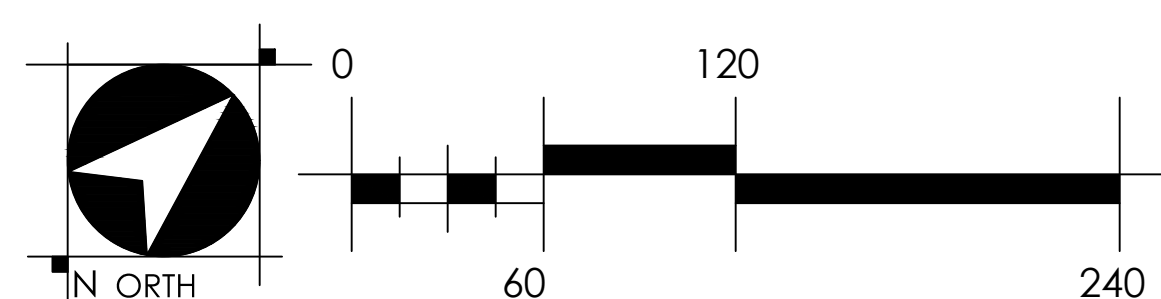

SOMERSVILLE ROAD




Rialto Parking Tabulation

Home Type	City Required				State Required			Parking Provided		
	BR Count	Homes	Garage (2 per unit)	Guest (1 per unit)	TOTAL	3-BR (1.5 per unit)	4-BR + (2.5 per unit)	TOTAL	Garage (2 per unit)	Guest (0.5 per unit)
3-BR	107	107	214	107	321	161		161	214	54
4-BR +	67	67	134	67	201		168	168	134	34
Total	174	174	348	174	522	161	168	329	348	88
Ratio					3:1			1.9:1		2.5:1

*All City required parking information is based on Antioch Municipal Code Table: § 9-5.1703.1.
*All State required parking information is based on Government Code 65915.(p)(1).
*The total parking provided tabulation does not include street parking.
*All provided guest parking will be standard spaces, there will be no accessible or compact spaces.


DISTRIBUTION TABLE

PLAN#	1	2	3	4	5	
	TWO-STORY 3-BEDROOMS	TWO-STORY 3-BEDROOMS	TWO-STORY 4-BEDROOMS	TWO-STORY 3-BEDROOMS +1-JR ADU	TWO-STORY 4-BEDROOMS +1-JR ADU	
LIVING	1,806 SQ. FT.	1,984 SQ. FT.	2,264 SQ. FT.	2,513 SQ. FT.	2,762 SQ. FT.	
GARAGE	436 SQ. FT.	419 SQ. FT.	426 SQ. FT.	426 SQ. FT.	502 SQ. FT.	
COUNT	56	51	53	11	3	174
PERCENT	32%	29%	31%	6%	2%	100%

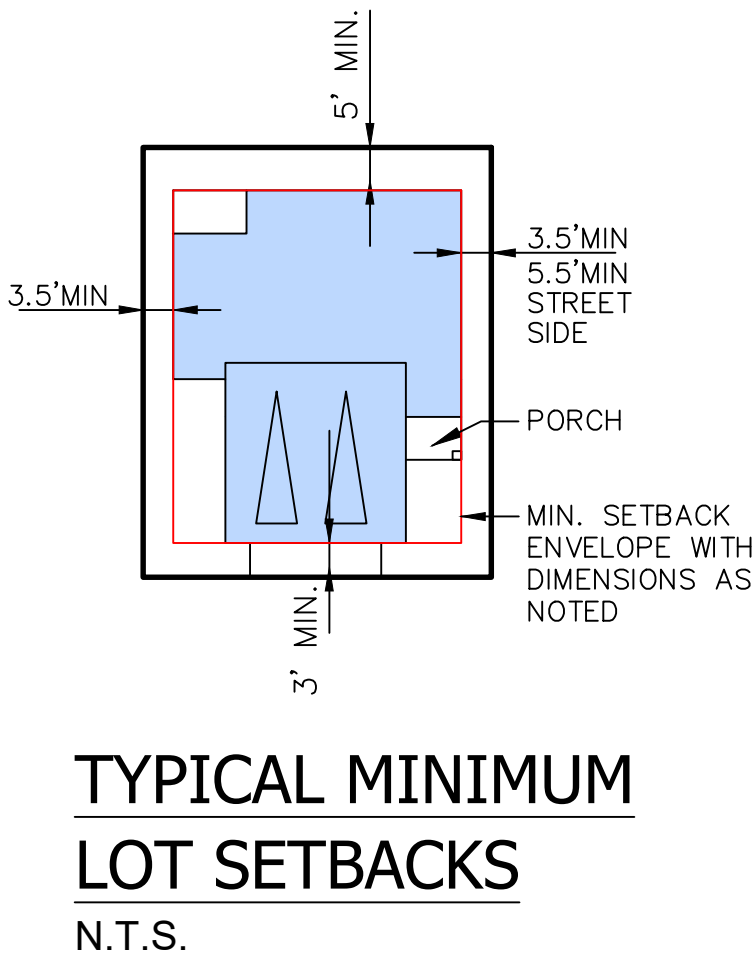

TYPICAL MINIMUM
LOT SETBACKS
N.T.S.

ENCROACHMENT ALLOWED UP TO 10 FEET IN
WIDTH BUT SHALL NOT INFRINGE INTO THE
MINIMUM 3-FOOT FIRE ACCESS.

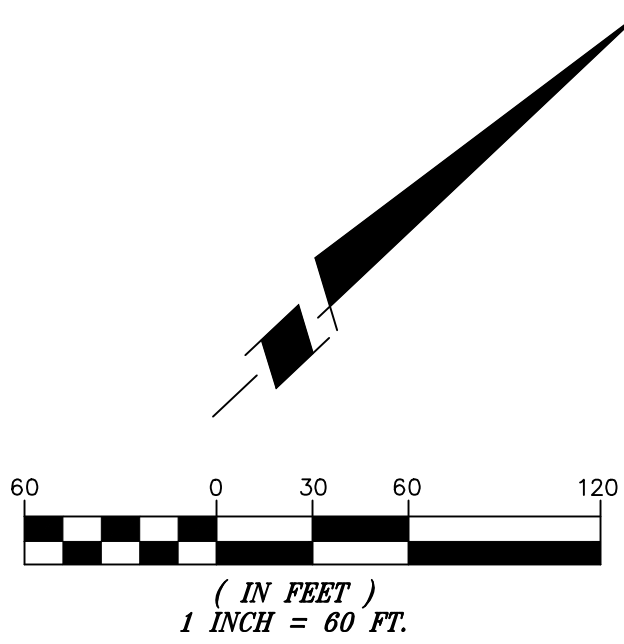

Rialto Affordable Housing Tabulation

Home Type	Number of Homes-----			SB330 lower-income	RHNA Reporting-----			
	Base Count	Bonus	Total		Very-Low	Low	Moderate	Above-Mod
3-BR	90	17	107	0	0	0	0	107
3-BR + JADU	0	11	11	11	11	0	0	11
4-BR	40	13	53	0	0	0	4	49
5-BR (shared-housing)	0	3	3	15	15	0	0	0
Total	130	44	174	26	26	0	4	167

* Project site is not zoned Residential.
* City does not have an affordable housing ordinance.
* "Base Count" is derived from the Project SB330 Preliminary Application (PA) of 108, increased by 20%, which is 130 SF homes.
* Project is providing 20% lower-income units under SB330. 20% of 130 = 26 (all @ very-low-income).
* 20% very-low-income units entitles the Project to 50% bonus. 130 * 1.50 = 195
* Dwelling units are not restricted to senior housing

MASTER PLOTTING PLAN

RIALTO PLACE
ANTIOCH ,CA

MAY 3, 2024

PERCENT LOT COVERAGE

Lot	Net Lot Area	Plan Type	Number of Bedrooms	Ground Floor Area	Percent Lot Coverage
1	2,139	2	3	1,188	56%
2	2,150	3	4	1,401	65%
3	2,345	1	3	1,127	48%
4	2,436	2	3	1,188	49%
5	2,186	3	4	1,401	64%
6	2,165	1	3	1,127	52%
7	2,231	2	3	1,188	53%
8	2,359	3	4	1,401	59%
9	2,655	1	3	1,127	42%
10	2,477	2	3	1,188	48%
11	2,195	3	4	1,401	64%
12	2,153	1	3	1,127	52%
13	2,240	1	3	1,127	50%
14	2,377	3	4	1,401	59%
15	2,674	2	3	1,188	44%
16	2,195	3	4	1,401	64%
17	2,153	2	3	1,188	55%
18	2,240	2	3	1,188	53%
19	2,377	3	4	1,401	59%
20	5,151	5	5	1,630	32%
21	2,477	2	3	1,188	48%
22	2,195	3	4	1,401	64%
23	2,153	1	3	1,127	52%
24	2,240	1	3	1,127	50%
25	2,377	3	4	1,401	59%
26	2,675	2	3	1,188	44%
27	2,151	3	4	1,401	65%
28	2,151	2	3	1,188	55%
29	2,149	2	3	1,188	55%
30	2,228	3	4	1,401	63%
31	4,841	5	5	1,630	34%
32	2,352	2	3	1,188	51%
33	2,150	3	4	1,401	65%
34	2,124	1	3	1,127	53%
35	2,909	2	3	1,188	41%
36	2,967	3	4	1,401	47%
37	2,989	2	3	1,188	40%
38	2,989	3	4	1,401	47%
39	2,967	1	3	1,127	38%
40	2,884	2	3	1,188	41%
41	2,124	1	3	1,127	53%
42	2,149	3	4	1,401	65%
43	2,179	2	3	1,188	55%
44	2,179	1	3	1,127	52%
45	2,148	3	4	1,401	65%
46	2,141	1	3	1,127	53%
47	2,349	1	3	1,127	48%
48	2,365	3	4	1,401	59%
49	2,397	2	3	1,188	50%
50	2,397	1	3	1,127	47%
51	2,365	3	4	1,401	59%
52	2,338	2	3	1,188	51%
53	2,992	1	3	1,127	38%
54	2,477	3	4	1,401	57%
55	2,427	1	3	1,127	46%
56	2,300	3	4	1,401	61%
57	2,667	2	3	1,188	45%
58	2,821	1	3	1,127	40%
59	2,365	3	4	1,401	59%

Lot	Net Lot Area	Plan Type	Number of Bedrooms	Ground Floor Area	Percent Lot Coverage
60	2,585	2	3	1,188	46%
61	2,585	1	3	1,127	44%
62	3,009	2	3	1,188	39%
63	2,571	1	3	1,127	44%
64	2,477	3	4	1,401	57%
65	2,477	1	3	1,127	45%
66	3,530	4	4	1,569	44%
67	3,012	1	3	1,127	37%
68	2,722	3	4	1,401	51%
69	2,722	1	3	1,127	41%
70	2,578	2	3	1,188	46%
71	2,186	1	3	1,127	52%
72	2,352	3	4	1,401	60%
73	2,523	1	3	1,127	45%
74	2,588	2	3	1,188	46%
75	3,569	2	3	1,188	33%
76	2,801	4	4	1,569	56%
77	2,886	2	3	1,188	41%
78	4,338	3	4	1,401	32%
79	3,242	1	3	1,127	35%
80	3,457	1	3	1,127	33%
81	2,478	1	3	1,127	45%
82	2,140	3	4	1,401	65%
83	3,627	2	3	1,188	33%
84	3,556	1	3	1,127	32%
85	3,228	3	4	1,401	43%
86	3,199	1	3	1,127	35%
87	3,381	4	4	1,569	46%
88	2,352	1	3	1,127	48%
89	2,148	2	3	1,188	55%
90	2,125	1	3	1,127	53%
91	2,352	3	4	1,401	60%
92	3,141	4	4	1,569	50%
93	2,226	2	3	1,188	53%
94	3,752	4	4	1,569	42%
95	3,672	3	4	1,401	38%
96	2,837	1	3	1,127	40%
97	2,905	2	3	1,188	41%
98	2,937	3	4	1,401	48%
99	2,933	2	3	1,188	41%
100	3,213	3	4	1,401	44%
101	3,756	4	4	1,569	42%
102	2,288	1	3	1,127	49%
103	2,645	3	4	1,401	53%
104	2,125	2	3	1,188	56%
105	2,150	3	4	1,401	65%
106	2,355	1	3	1,127	48%
107	2,125	1	3	1,127	53%
108	2,150	3	4	1,401	65%
109	2,860	2	3	1,188	42%
110	3,544	1	3	1,127	32%
111	2,150	3	4	1,401	65%
112	2,125	2	3	1,188	56%
113	2,768	1	3	1,127	41%
114	2,752	3	4	1,401	51%
115	3,520	3	4	1,401	40%
116	3,993	3	4	1,401	35%
117	3,282	2	3	1,188	36%
118	2,516	1	3	1,127	45%


Lot	Net Lot Area	Plan Type	Number of Bedrooms	Ground Floor Area	Percent Lot Coverage
119	2,149	3	4	1,401	65%
120	2,731	2	3	1,188	43%
121	3,314	4	4	1,401	42%
122	2,136	2	3	1,188	56%
123	2,338	1	3	1,127	48%
124	2,352	3	4	1,401	60%
125	2,352	1	3	1,127	48%
126	2,125	2	3	1,188	56%
127	2,594	3	4	1,401	54%
128	2,629	1	3	1,127	43%
129	2,107	2	3	1,188	56%
130	2,025	1	3	1,127	56%
131	2,880	2	3	1,188	41%
132	2,797	3	4	1,401	50%
133	2,773	2	3	1,188	43%
134	3,672	4	4	1,569	43%
135	2,678	1	3	1,127	42%
136	2,645	3	4	1,401	53%
137	3,180	1	3	1,127	35%
138	2,466	2	3	1,188	48%
139	2,150	3	4	1,401	65%
140	2,125	2	3	1,188	56%
141	2,125	2	3	1,188	56%
142	2,150	3	4	1,401	65%
143	4,728	5	5	1,630	34%
144	2,363	2	3	1,188	50%
145	2,150	3	4	1,401	65%
146	2,125	1	3	1,127	53%
147	2,125	1	3	1,127	53%
148	2,150	3	4	1,401	65%
149	2,363	2	3	1,188	50%
150	2,362	1	3	1,127	48%
151	2,150	3	4	1,401	65%
152	2,125	2	3	1,188	56%
153	2,125	1	3	1,127	53%
154	2,150	3	4	1,401	65%
155	2,361	1	3	1,127	48%
156	2,352	1	3	1,127	48%
157	2,150	3	4	1,401	65%
158	2,124	2	3	1,188	56%
159	2,672	2	3	1,188	44%
160	2,592	1	3	1,127	43%
161	2,592	2	3	1,188	46%
162	3,280	1	3	1,127	34%
163	4,048	4	4	1,569	39%
164	3,308	3	4	1,401	42%
165	3,540	4	4	1,569	44%
166	2,795	1	3	1,127	40%
167	2,633	2	3	1,188	45%
168	2,433	3	4	1,401	58%
169	2,314	1	3	1,127	49%
170	2,125	1	3	1,127	53%
171	2,800	1	3	1,127	40%
172	3,194	3	4	1,401	44%
173	4,805	4	4	1,569	33%
174	2,908	2	3	1,188	41%
NOTE: Percent of net lot area covered by buildings is the same as percent lot coverage.					

MASTER PLOTTING PLAN SITE DATA

RIALTO PLACE
ANTIOCH, CA

MAY 3, 2024


LEGACY BUILDERS. INC
RIALTO PLACE
ANTIOCH CONTRA COSTA COUNTY CALIFORNIA

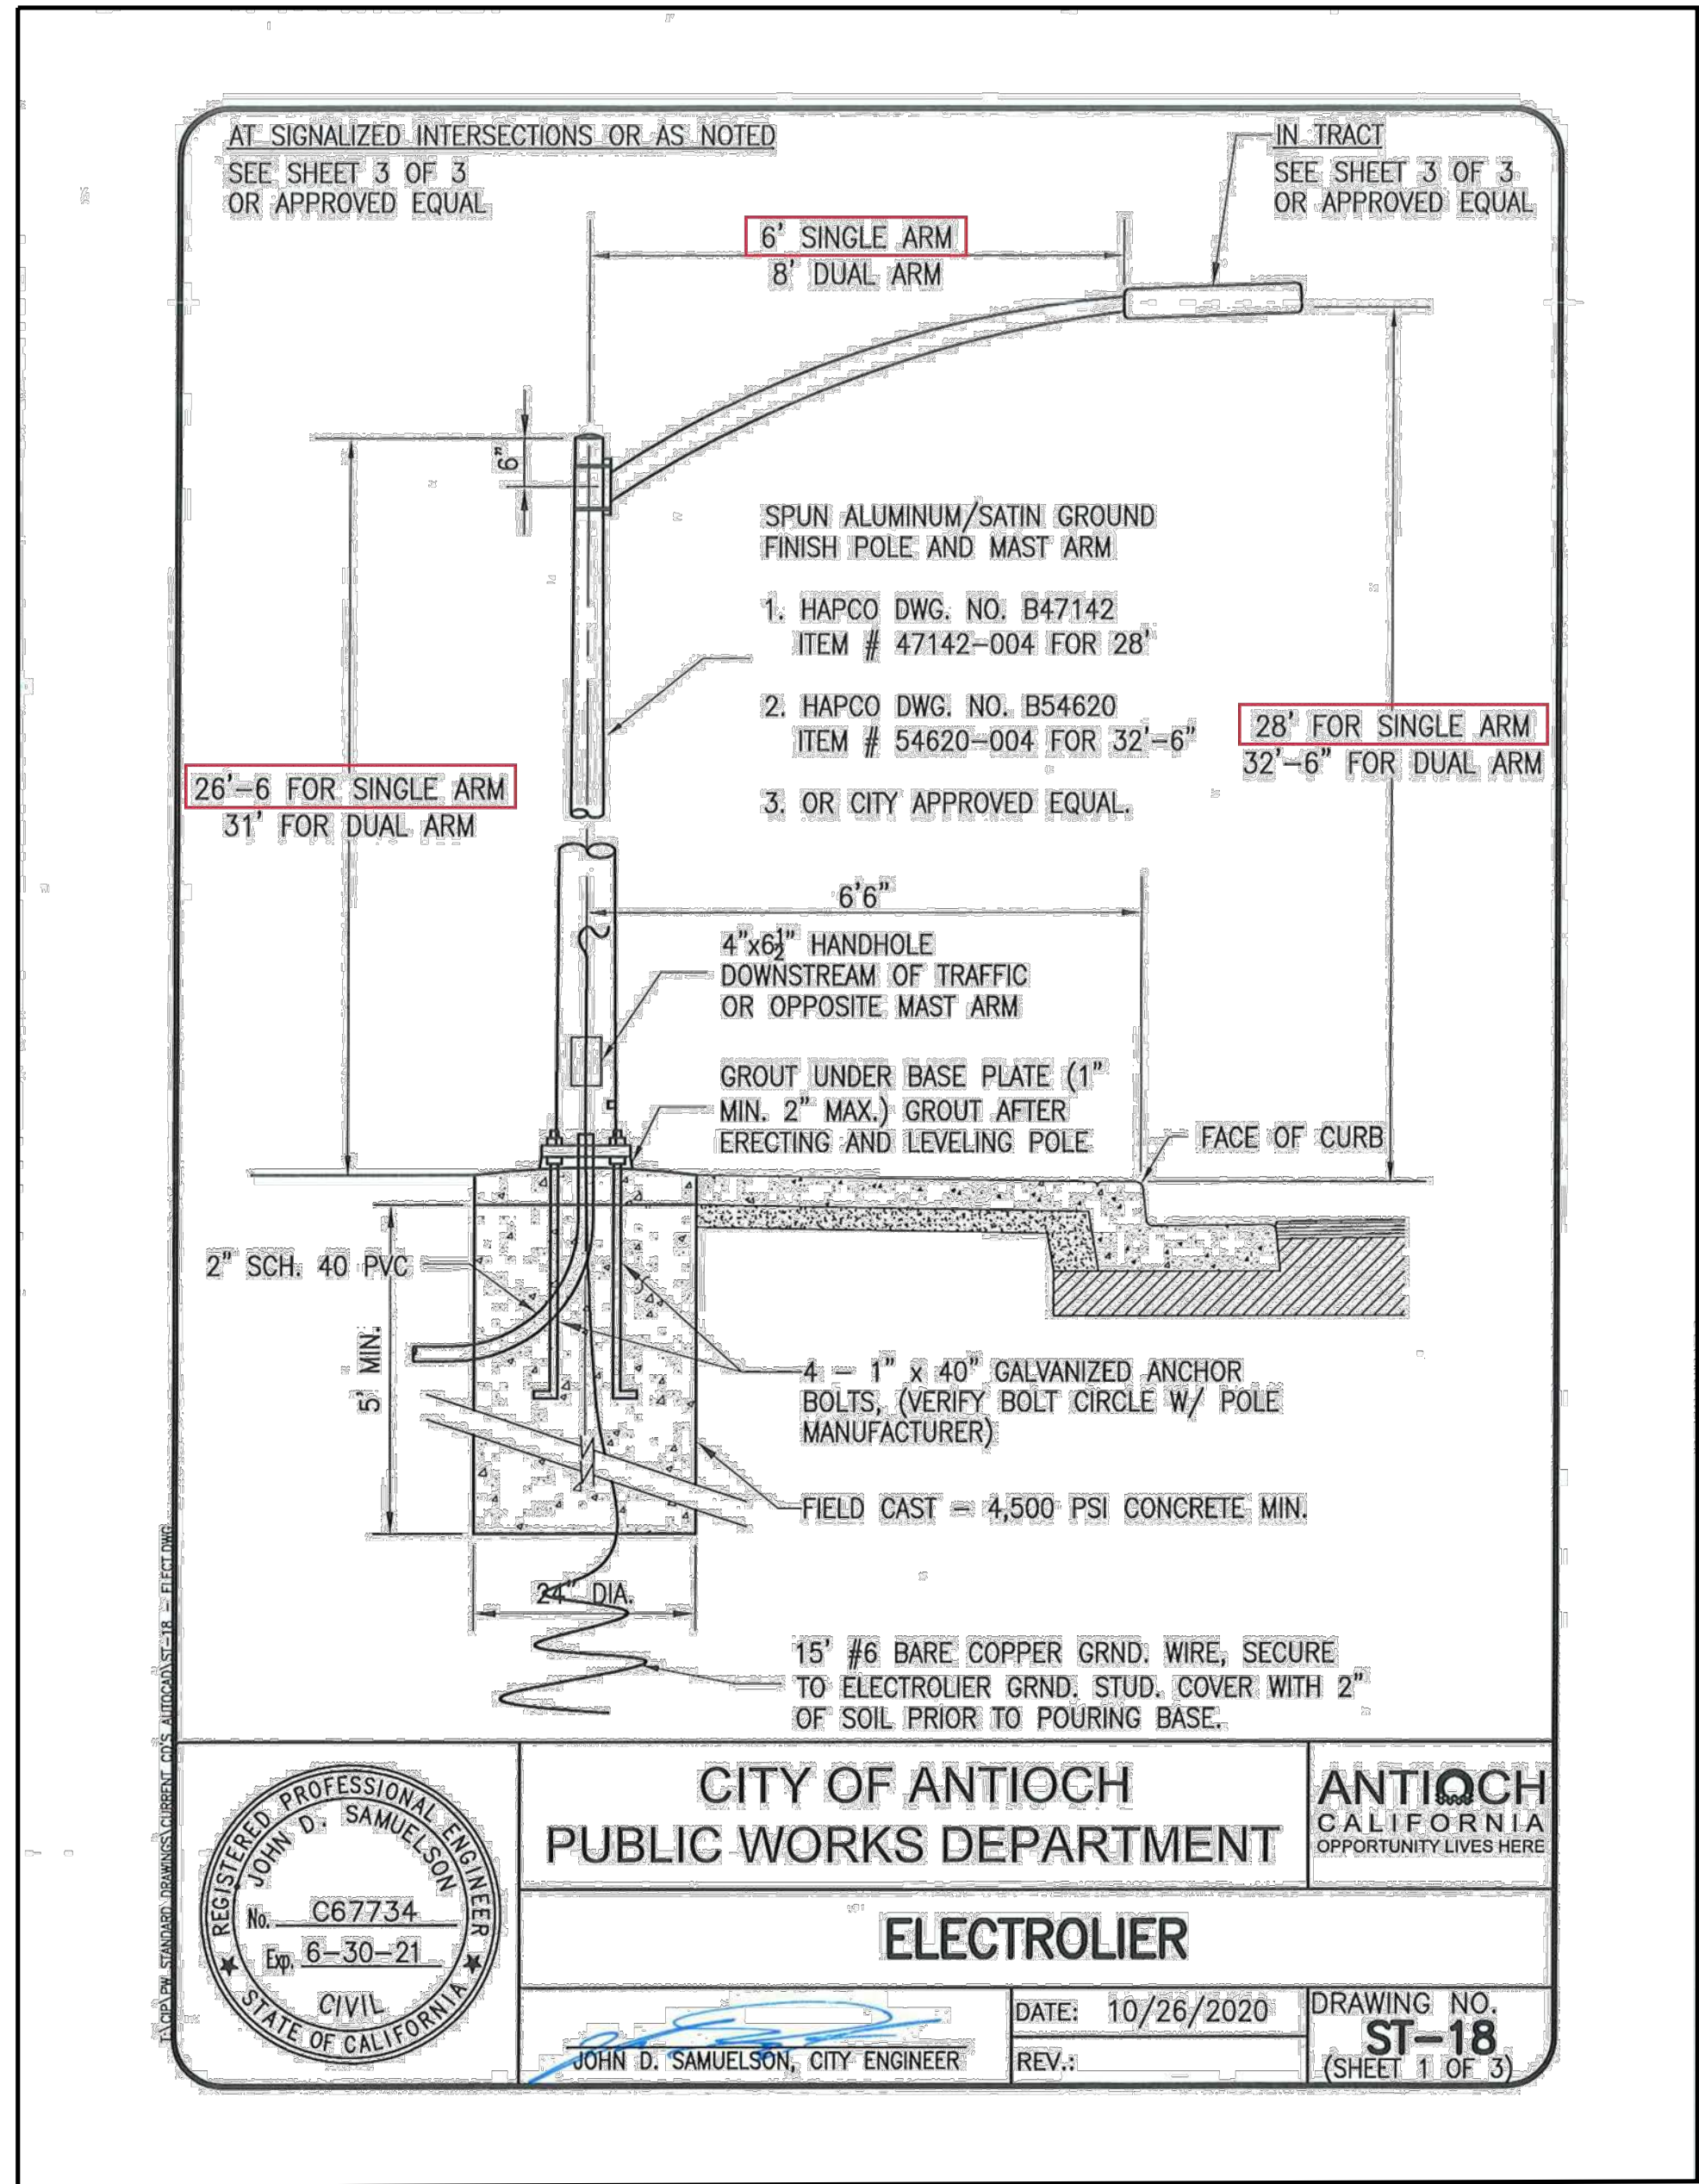

1 PUBLIC STREET LIGHT DETAIL
SL1 NOT TO SCALE

LEGEND

— ESL — EXISTING STREET LIGHT CONDUIT
— SL — PROPOSED STREET LIGHT CONDUIT
X'(XX"S.L. COND.) STREET LIGHTING CONDUIT LABEL, X' INDICATES CONDUIT LENGTH, (XX"S.L. COND.) INDICATES CONDUIT SIZE
X'(XX) STREET LIGHTING WIRE LABEL, X' INDICATES WIRE LENGTH, (XX) INDICATES WIRE TYPE
(2W) 2-#8 CU. WIRE (SEE NOTE 15)
(3W) 3-#8 CU. WIRE (SEE NOTE 15)
(3WG) 2-#8 CU. WIRE & 1-#8 BARE CU. GROUND (UNLESS OTHERWISE NOTED); SEE NOTE 15 & GROUNDING DETAIL
(4WG) 3-#8 CU. WIRE & 1-#8 BARE CU. GROUND (UNLESS OTHERWISE NOTED); SEE NOTE 15 & GROUNDING DETAIL
EXISTING TRAFFIC SIGNAL
STREET LIGHTING PULL BOX STATE TYPE #3 1/2, 10" x 17" x 12"
STREET LIGHTING GROUND BOX STATE TYPE #5, 13" x 24" x 12"
PROPOSED PUBLIC STREET LIGHT, SINGLE ARM
EXISTING STREET LIGHT, DOUBLE ARM
CIRCUIT NUMBER/PHASE (SEE ELECTRIC SOURCE DETAILS)
POLE NUMBER
STREET LIGHT POINT OF SERVICE
FACE OF CURB

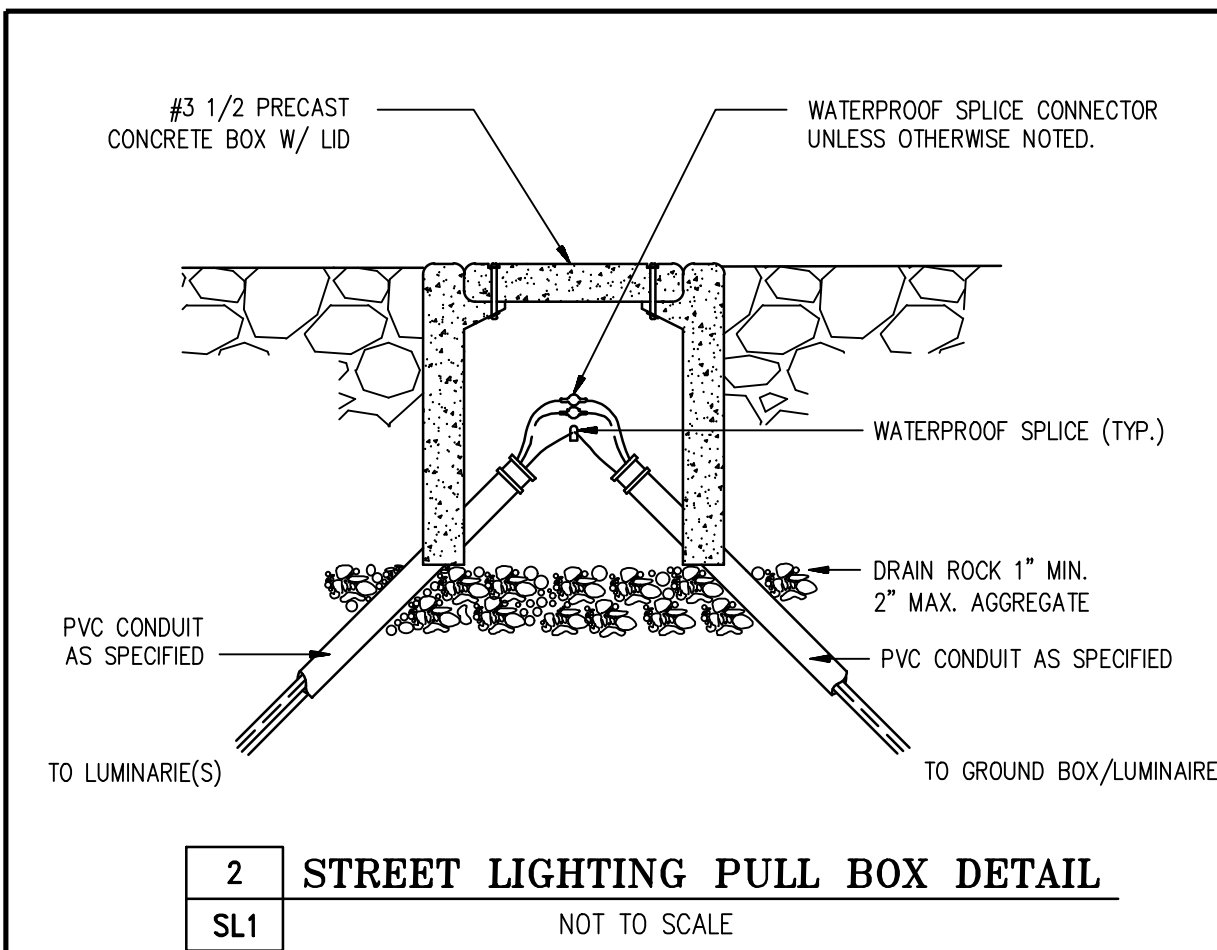


**CONSTRUCTION LABOR AND
MATERIAL RESPONSIBILITY**
**STREET LIGHTING SYSTEM
(PUBLIC)**

WIRE:	CONTRACTOR
FURNISH:	
INSTALL:	
CONDUIT:	
FURNISH:	
INSTALL:	
BASES:	
FURNISH:	
INSTALL:	
LUMINAIRES:	
FURNISH:	
INSTALL:	
SPLICE BOXES:	
FURNISH:	
INSTALL:	
EXCAVATE:	
POLES & ARMS:	
FURNISH:	
INSTALL:	


SCHEDULE:	LS2A
INSTALL IN JOINT TRENCH:	YES
INSTALL IN SEPARATE TRENCH:	YES
CONDUIT SIZE:	1 1/2"
CONDUIT TYPE:	SCH. 40
WIRE SIZE:	#8
TYPE:	CU

ADDITIONAL NOTES:
-DEVELOPER TO SUPPLY AND INSTALL
ELECTRIC FACILITIES UNDER THE COMPETITIVE
BIDDING PROVISIONS OF PG&E GREEN BOOK
RULES 15, 16 AND 20.
-STREET LIGHTS TO BE MAINTAINED BY
LANDSCAPING DISTRICT #X-X', UPON TRACT
ACCEPTANCE.
-SEE JOINT TRENCH COMPOSITE FOR TRENCH.

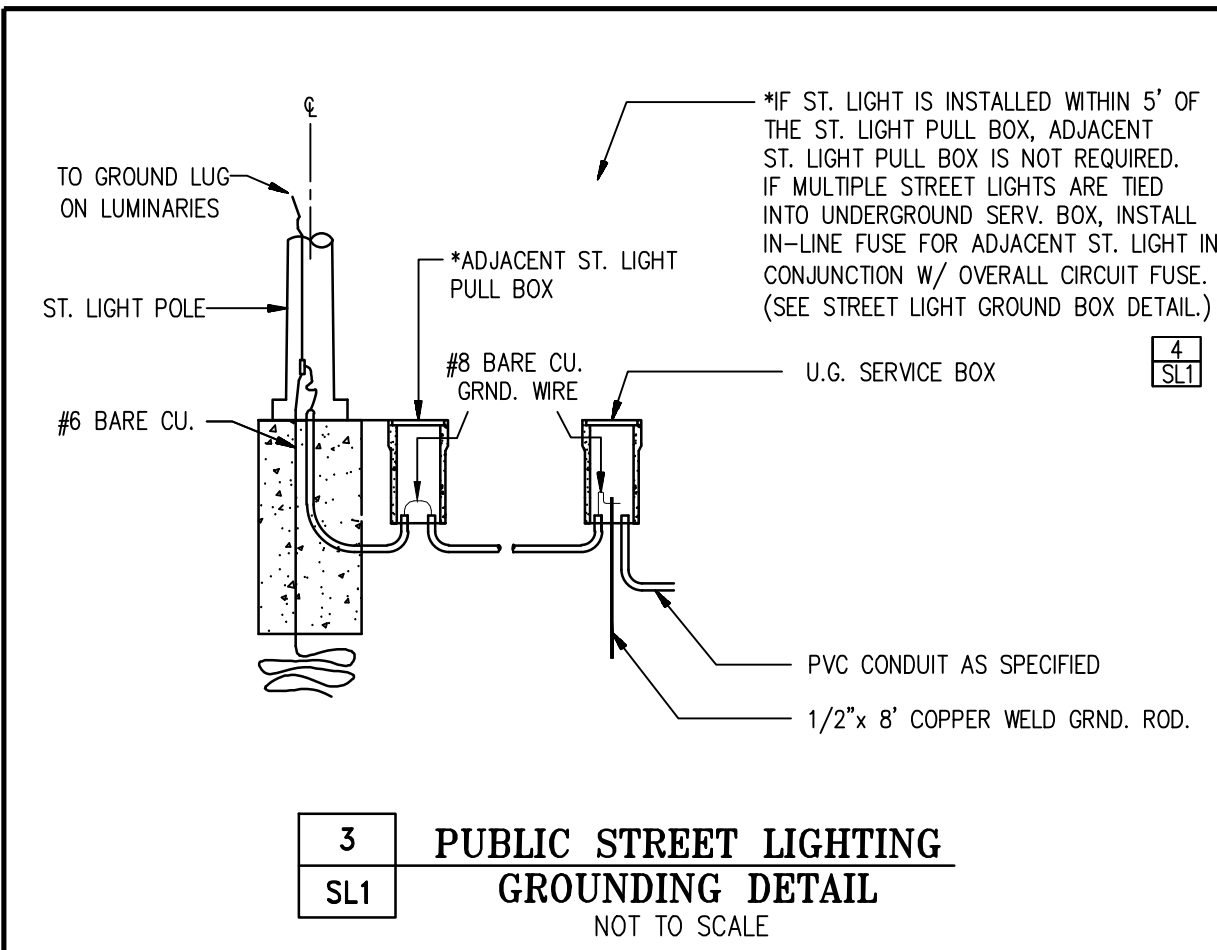

STREET LIGHTING NOTES


- ALL MATERIAL AND WORKMANSHIP SHALL FULLY CONFORM WITH THE NATIONAL ELECTRIC CODE AND STANDARD SPECIFICATIONS AND DETAILS OF THE CITY OF ANTIOCH.
- THE ELECTRICAL CONTRACTOR SHALL INSTALL THE UNDERGROUND SERVICE FROM THE LUMINAIRE TO PG&E SERVICE POINT AND TERMINATE CONDUIT AND WIRES AT BOX AS DIRECTED BY THE CITY.
- KEEP STREET LIGHTS A MINIMUM OF 3 FEET AWAY FROM THE EDGE OF DRIVEWAYS, SEWER AND WATER LATERALS AND 5 FEET AWAY FROM FIRE HYDRANTS & CATCH BASINS.
- TWO OR MORE STREET LIGHTS ON THE SAME CIRCUIT SHALL BE WIRED TO BALANCE THE LOAD. (SEE WIRING DIAGRAM), UNLESS OTHERWISE NOTED.
- CONDUIT AND FITTINGS:** ALL CONDUIT AND FITTINGS SHALL BE U.L. APPROVED SCHEDULE 40 P.V.C., USE MINIMUM 1 1/2" SCH. 40 P.V.C. CONDUIT AND FITTINGS BELOW GRADE, UNLESS OTHERWISE NOTED OR REQUIRED. MINIMUM RADIUS BENDS SHALL BE 18". FOR ABOVE GROUND INSTALLATION USE METALLIC RIGID STEEL CONDUIT. PROVIDE PULL WIRE IN EMPTY CONDUITS. ALL CROSSINGS TO BE PERPENDICULAR TO STREET.
- CONDUIT DEPTH:** 24" UNDER SIDEWALK; 24" UNDER PLANTER STRIP; 30" UNDER PAVEMENT.
- CABLE:** CABLE SHALL BE U.L. A.W.G. NO. 8, 7-STRAND SOFT COPPER, TYPE THW OR THWN WITH MINIMUM OF 3/64" (40 MIL) POLYVINYL CHLORIDE INSULATION, UNLESS OTHERWISE NOTED. U.L. LISTED 600 VOLT, NO. 10 IN POLE MAY BE USED (40 MIL INSULATION).
- SPLICE BOXES:** SPLICE BOXES SHALL BE NO. 3-1/2 STATE TYPE WITH LID AND BRASS HOLD DOWN BOLTS, UNLESS OTHERWISE NOTED. LIDS TO BE INSCRIBED 'STREET LIGHTING'. SPLICE BOXES SHALL NOT BE MORE THAN 200 FEET APART ON LONG RUNS. SPLICE BOXES TO BE SET ON A CONCRETE FOOTING WHEN SUBJECT TO TRAFFIC LOAD.
- FUSES:** EACH POLE SHALL BE FUSED WITH WATERPROOF IN-LINE FUSE HOLDERS AT EACH ADJACENT BOX WITH 5 AMP FUSE. FOR DUPLEX LIGHTS, EACH LUMINAIRE SHALL BE FUSED SEPARATELY.
- SPLICING:** ALL SPLICES SHALL BE MADE IN HAND HOLES OR SPLICE BOXES ONLY. SPLICES SHALL BE MADE WITH "STACK -ON" CRIMP JOINTS, "SCOTCH LOCK" FASTENERS, OR APPROVED EQUAL. ON SPLICES MADE BELOW GRADE, WRAP WITH MOISTURE PROOF INSULATION THICKNESS.
- POLE NUMBERS:** OBTAIN AND PLACE POLE NUMBERS ON ALL STREET LIGHT STANDARDS AS REQUIRED. COORDINATE WITH PG&E AND/OR CITY FOR THEIR REQUIREMENTS.
- TRENCH:** CONDUIT CAN BE PLACED IN JOINT TRENCH. THE CONDUIT LAYOUT IS SHOWN SCHEMATICALLY. SEE COMPOSITE DRAWING FOR TRENCH AND BOX LOCATIONS. ANY INCIDENTAL TRENCHING NOT PROVIDED BY TRENCHING AGENT IS CONTRACTOR'S RESPONSIBILITY.
- THE CONTRACTOR SHALL BE HELD RESPONSIBLE FOR ANY FIELD CHANGES MADE WITHOUT FIRST NOTIFYING TARRAR UTILITY CONSULTANTS.
- TARRAR UTILITY CONSULTANTS ASSUMES NO RESPONSIBILITY FOR ANY VARIANCE BETWEEN THESE PLANS AND THE ACTUAL FIELD CONDITIONS. CONTRACTOR SHOULD REVIEW PROJECT SITE PRIOR TO SUBMITTING ITS BID.
- CONTRACTOR TO CONSULT WITH LOCAL AGENCIES FOR THEIR CIRCUIT GROUNDING REQUIREMENTS. IF GROUND WIRE IS REQUIRED IN CONDUIT, INSTALL ACCORDINGLY.
- LEGEND SYMBOLS ARE SHOWN IN STREET AREA FOR CLARITY. INSTALL BEHIND CURB AND/OR SIDEWALK PER THE CITY SPECIFICATIONS KEEP CLEAR OF DRIVEWAYS AND PATHWAYS (TYPICAL).
- CENTERLINE OF STREET LIGHTS SHALL BE LOCATED ON THE LOT LINE UNLESS OTHERWISE NOTED ON THESE PLANS.
- ANY CHANGES OR MODIFICATIONS TO PROPOSED STREET LIGHT LOCATIONS SHALL BE APPROVED, IN WRITING, BY THE CITY PRIOR TO INSTALLATION.
- SET ALL STREET LIGHTS TO ULTIMATE FINISHED GRADE. CONSULT WITH CITY FOR PROPER PHYSICAL PROTECTION AND/OR SIGNING AND STRIPING ADJACENT TO ANY STREET LIGHTS INSTALLED IN THEIR ULTIMATE LOCATIONS THAT ARE NOT PROTECTED BY A VERTICAL CURB. BERM AND COMPACT EARTH TO FINISHED GRADE A MINIMUM OF 5' AROUND STREET LIGHT BASES AT THESE LOCATIONS.
- CONTACT U.S.A. (2) FULL WORKING DAYS PRIOR TO STARTING WORK IF EXISTING UTILITIES CONFLICT WITH POLE LOCATION, FIELD ADJUST TO CLEAR EXISTING UTILITIES A MINIMUM OF 3'-0".
- STREET LIGHT CONDUIT BENDS SHALL HAVE A MINIMUM 18" RADIUS. UNLESS OTHERWISE SHOWN ON THE PLANS, NO BEND SHALL BE INSTALLED IN THE STREET LIGHT SYSTEM WITHOUT PRIOR APPROVAL OF THE CITY INSPECTOR.
- ALL BOXES ARE TO BE INSTALLED WITHIN THE R/W AND/OR P.U.E. AREA.

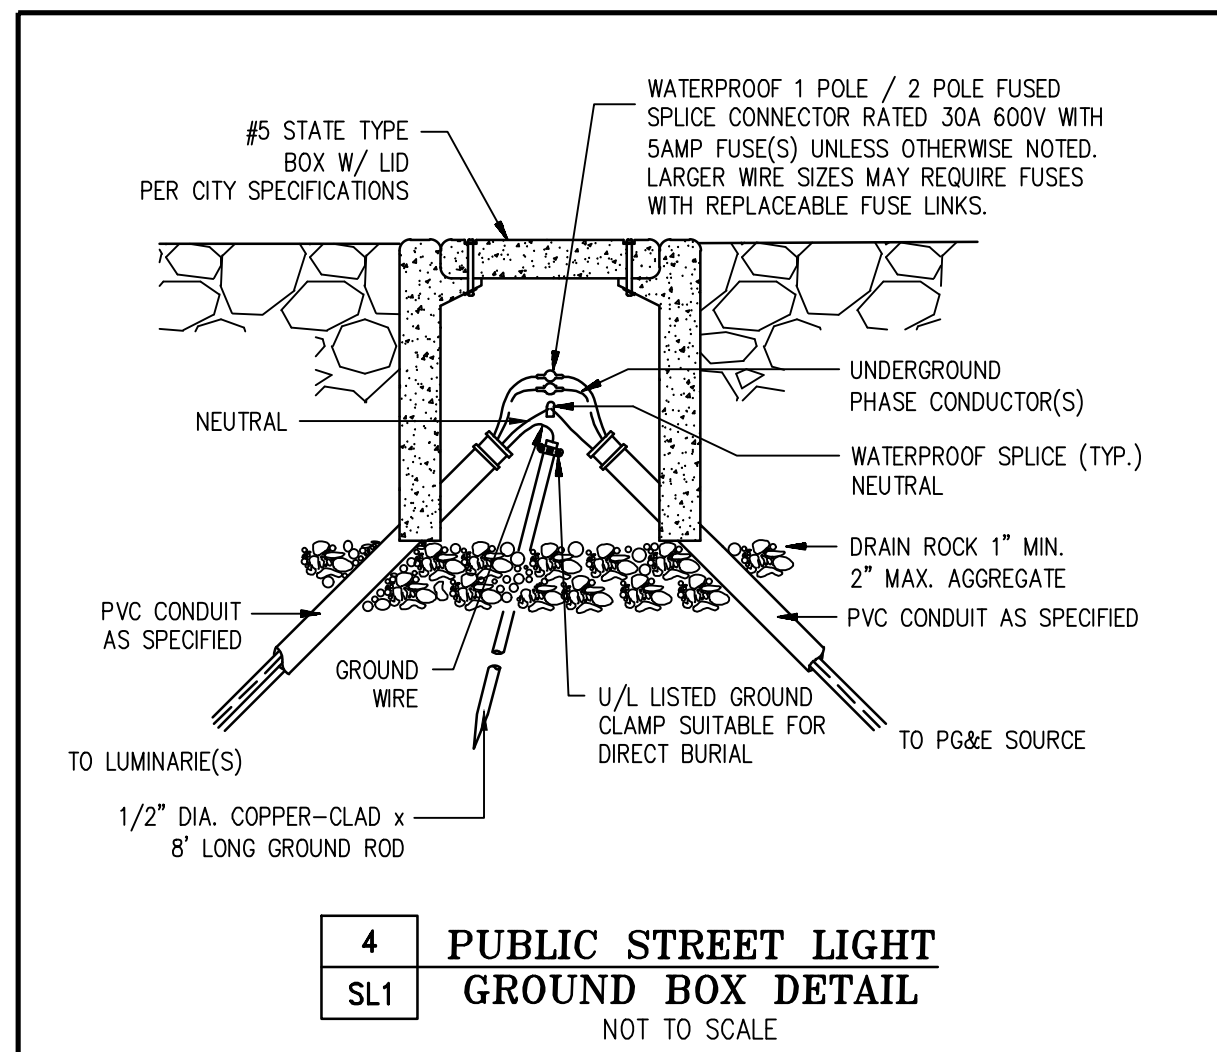

STREET LIGHTING GENERAL NOTES AND DETAILS
LEGACY BUILDERS. INC
RIALTO PLACE
ANTIOCH CALIFORNIA

NO.	REVISIONS	BY	DATE

DATE: April 2024	DATE LAST WORKED ON: 5/3/2024
SCALE: NOT TO SCALE	DRAWN: SM
JOB NO.: 224054	CHECKED: KT
PRELIMINARY NOT FOR CONSTRUCTION	
INTENT TO CONSTRUCT	

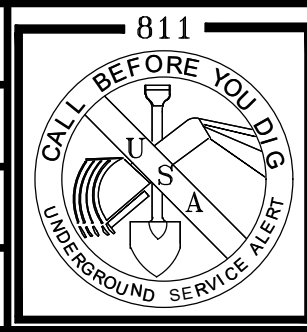

SHEET
SL1
SL4
OF
SHEETS


813 First Street
Brentwood, CA 94513
(925) 240-2595
(925) 240-7013 fax
www.tarrar.com

TARRAR
UTILITY CONSULTANTS

- Planning
- Design
- Estimating
- Joint Trench
- Street Lighting
- Fiber Optic
- T-24
- PG&E Gas Design
- PG&E Elec Design
- M.E.P. Design
- Cost Analysis
- Due Diligence

LEOTEK®

GreenCobra™ Jr. LED Streetlight
GCJ J-Series Specification Data Sheet

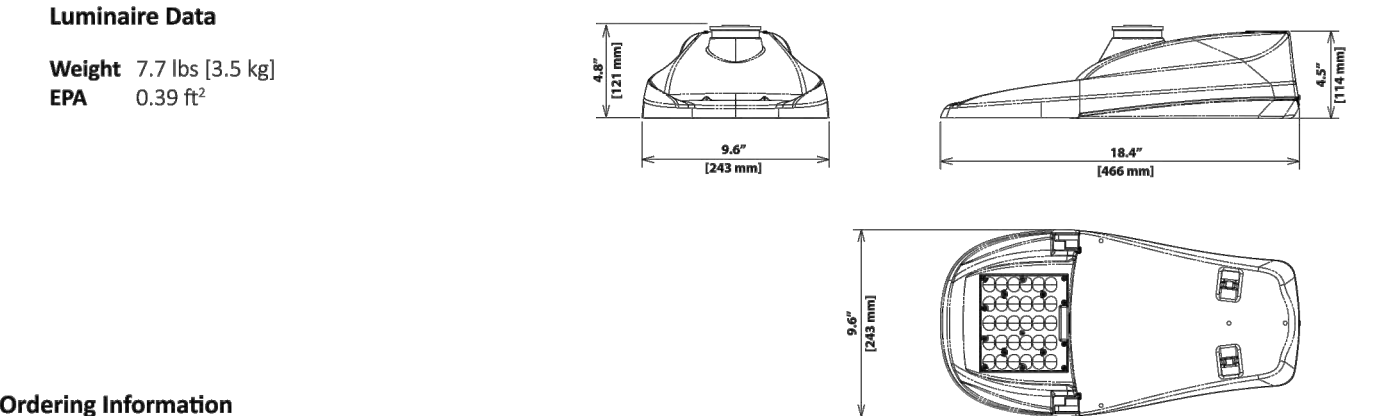

Ordering Information

Sample Catalog No. GCJ1-30J-MV-40K-2R-GY-05S-PCR7-WL

GCJ1	30J	MV	40K	2R	GY	050	PCR7-WL
Model*	LED Code	Voltage	Color Temperature	Distribution	Finish*	Output Code*	Options
GCJ1*	30J	MV 120-277V	22K 2200K	2R Type 2	GY Gray	Refer to page 3 and 4 to select the output code.	FOC ¹ Fixed Output Code LPCR ² Less Photocontrol Receptacle ANSI 7-wire Photocontrol Receptacle Control Ready 7-wire PC Receptacle
GCJ2*		HV 347-480V	27K 2700K	3R Type 3R	DB Dark Bronze		MSL3 Motion Sensor, L3 Lens MSL7 Motion Sensor, L7 Lens Utility Wattage Label 4-Bolt Mounting Bracket RWG Rubber Wildlife Guard SWTB Straight Wire Terminal Block BBL Bubble Level DSC Door Safety Cable CF Coastal Paint Finish SP2 ³ Extreme Surge Protection, 20KV/10KA, Fail-to-on LSSP2 ³ Extreme Surge Protection, Fail-to-off, 20KV/10KA Rating
GCJ3*			30K 3000K	4 Type 3F	BK Black		
GCJ4*			40K 4000K	5 Type 5			
			50K 5000K				

* Refer to performance data table on page 3, 4 for specific model with corresponding output code

Notes:

- Gray, Black, and Dark Bronze standard. Consult factory for other finishes. See page 2 for IAL codes of Standard finishes.
- Specified output code is the factory set lumen performance. Refer to performance data table on page 3, 4 of this spec sheet.
- Field adjustable output selector enables future to be changed in the field to adjust light output for local conditions (not available with Fixed Output Code, FOC) or PCR7-CK option. Consult factory if wattage limits require a special drive current.
- Non-field adjustable, fixed output code. Specify required output code. Not available with PCR7-CK option.
- Includes output selector that enables field adjustability of light levels. Includes connectors to allow easy upgrade of wireless dimming via PCR7. Wireless node by others.
- Control ready wired at factory for wireless node dimming (node by others). Output selector not included in the future. Not able to adjust above specified output code.
- Specify the CF Option for coastal installation. See warranty for details.
- Standard surge protection, 10KV/5KA, fail-to-on, meets enhanced surge protection based on ANSI 136.25-2013 3-part test.
- Flush mounted house side shield. Shield cuts light off at 1 mounting height behind luminaire. Gray frame with black louvers.
- Flush mounted cut-de-sac shield. Shield cuts light off at 1 mounting height behind luminaire and 2 times the mounting height on either side of luminaire. Gray frame with black louvers.
- Flush mounted front side shield cuts light off at approximately 15x mounting height in front of luminaire (street side). Gray frame with black louvers.
- Specify Color (GY, DB, BK). Refer to Lextek web site for specific mounting details and drawings at <https://leotek.com/lighting-library/>
- Specify MV (120-277V) or HV (347-480V).

LEOTEK®

GreenCobra™ Jr. LED Streetlight
GCJ J-Series Specification Data Sheet

Performance Data: 3000K (30K)

All data nominal. IES files for all CCTs available at leotek.com.

Product	LED Code	Output Code	System Wattage (W)	Delivered Lumens (lm)¹	Efficacy (lm/W)	Field Adjustable Output Range
GCJ1	30J	025	17	2533	149	↕
		040	27	4058	152	
		045	30	4560	152	
		050	34	5223	154	
		055	37	5550	150	
GCJ2	30J	065	44	6425	146	↕
		070	49	7062	145	
		075	54	7722	143	
		080	58	8236	142	
		090	64	8960	140	
GCJ3	30J	095	67	9380	140	↕
		105	70	10490	150	
		115	80	11637	145	
		125	87	12428	143	
		135	100	13730	137	
GCJ4	30J	135	100	13730	137	↕
		145	110	14988	157	
		120	80	12207	153	
		130	87	13047	150	
		145	100	14399	144	

Notes:

- Nominal lumens. Normal tolerance ± 10% due to factors including distribution type, LED bin variance, and ambient temperatures.
- Maximum LED drive current is 500mA.

Performance Data: 4000K (40K) and 5000K (50K)

All data nominal. IES files for all CCTs available at leotek.com.

Product	LED Code	Output Code	System Wattage (W)	Delivered Lumens (lm)¹	Efficacy (lm/W)	Field Adjustable Output Range
GCJ1	30J	025	17	2669	157	↕
		045	27	4299	161	
		050	30	4830	161	
		055	34	5532	163	
		060	37	5883	159	
GCJ2	30J	070	44	6864	156	↕
		075	49	7256	149	
		080	54	7992	148	
		085	58	8468	146	
		090	64	9216	144	
GCJ3	30J	095	67	9648	144	↕
		110	70	10988	157	
		120	80	12207	153	
		130	87	13047	150	
		145	100	14399	144	
GCJ4	30J	145	100	14399	144	↕
		155	110	15657	150	
		125	87	13047	150	
		135	94	13307	144	
		145	100	14399	144	

Notes:

- Nominal lumens. Normal tolerance ± 10% due to factors including distribution type, LED bin variance, and ambient temperatures.
- Maximum LED drive current is 500mA.

©2024 LEOTEK Electronics USA. GCJ4_J-Series_Specification Sheet_31-January-2024. Specifications subject to change without notice.

Page 4 of 7

1 PUBLIC LUMINAIRE DETAIL
SL2 NOT TO SCALE

STREET LIGHTING GENERAL NOTES AND DETAILS

LEGACY BUILDERS. INC


RIALTO PLACE

ANTIOCH CALIFORNIA

- Planning
- Design
- Estimating
- Joint Trench
- Street Lighting
- Fiber Optic
- T-24
- PG&E Gas Design
- PG&E Elec Design
- M.E.P. Design
- Cost Analysis
- Due Diligence

NO.	REVISIONS	BY	DATE

DATE: April 2024	DATE LAST WORKED ON: 5/3/2024
SCALE: NOT TO SCALE	DRAWN: SM
JOB NO.: 224054	CHECKED: KT
PRELIMINARY NOT FOR CONSTRUCTION	
INTENT TO CONSTRUCT	

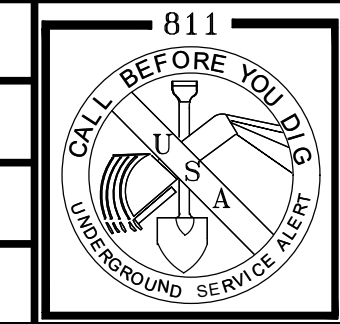


FOR REVIEW ONLY

SHEET
SL2
SL4
OF
SHEETS

LEOTEK®

GreenCobra™ Jr. LED Streetlight
GCJ J-Series Specification Data Sheet

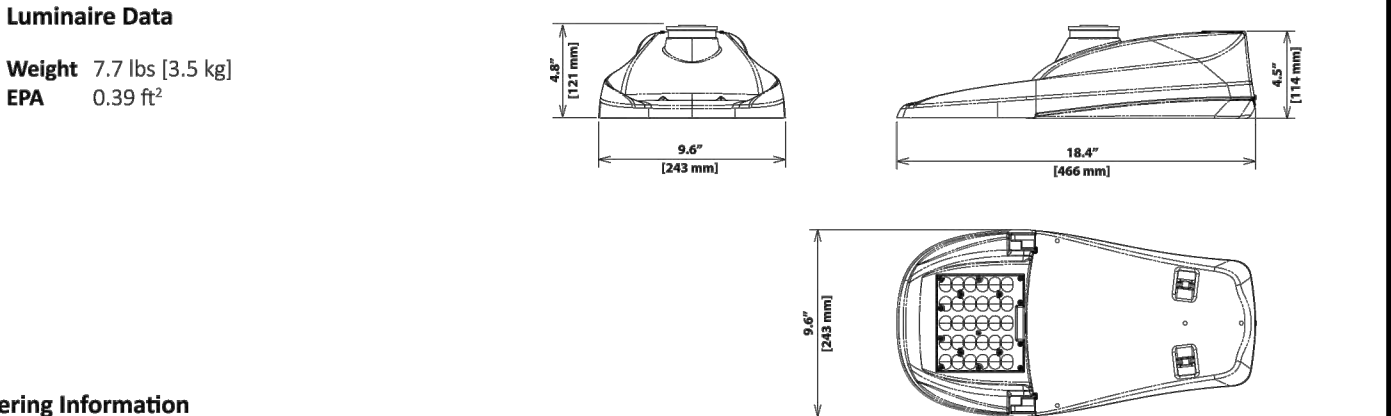

Ordering Information

Sample Catalog No. GCJ1-30J-MV-40K-2R-GY-05S-PCR7-WL

GCJ1	30J	MV	40K	3R	GY	050	PCR7-WL
Model*	LED Code	Voltage	Color Temperature	Distribution	Finish*	Output Code*	Options
GCJ1*	30J	MV 120-277V	22K 2200K	2R Type 2	GY Gray	Refer to page 3 and 4 to select the output code.	FOC ¹ Fixed Output Code LPCR ² Less Photocontrol Receptacle ANSI 7-wire Photocontrol Receptacle Control Ready 7-wire PC Receptacle
GCJ2*		HV 347-480V	27K 2700K	3R Type 3R	DB Dark Bronze		MSL3 Motion Sensor, L3 Lens MSL7 Motion Sensor, L7 Lens Utility Wattage Label 4-Bolt Mounting Bracket RWG Rubber Wildlife Guard SWTB Straight Wire Terminal Block BBL Bubble Level DSC Door Safety Cable CF Coastal Paint Finish SP2 ³ Extreme Surge Protection, 20KV/10KA, Fail-to-on LSSP2 ³ Extreme Surge Protection, Fail-to-off, 20KV/10KA Rating
GCJ3*			30K 3000K	4 Type 3F	BK Black		
GCJ4*			40K 4000K	5 Type 5			
			50K 5000K				

* Refer to performance data table on page 3, 4 for specific model with corresponding output code

Notes:

- Gray, Black, and Dark Bronze standard. Consult factory for other finishes. See page 2 for IAL codes of Standard finishes.
- Specified output code is the factory set lumen performance. Refer to performance data table on page 3, 4 of this spec sheet.
- Field adjustable output selector enables future to be changed in the field to adjust light output for local conditions (not available with Fixed Output Code, FOC) or PCR7-CK option. Consult factory if wattage limits require a special drive current.
- Non-field adjustable, fixed output code. Specify required output code. Not available with PCR7-CK option.
- Includes output selector that enables field adjustability of light levels. Includes connectors to allow easy upgrade of wireless dimming via PCR7. Wireless node by others.
- Control ready wired at factory for wireless node dimming (node by others). Output selector not included in the future. Not able to adjust above specified output code.
- Specify the CF Option for coastal installation. See warranty for details.
- Standard surge protection, 10KV/5KA, fail-to-on, meets enhanced surge protection based on ANSI 136.25-2013 3-part test.
- Flush mounted house side shield. Shield cuts light off at 1 mounting height behind luminaire. Gray frame with black louvers.
- Flush mounted cut-de-sac shield. Shield cuts light off at 1 mounting height behind luminaire and 2 times the mounting height on either side of luminaire. Gray frame with black louvers.
- Flush mounted front side shield cuts light off at approximately 15x mounting height in front of luminaire (street side). Gray frame with black louvers.
- Specify Color (GY, DB, BK). Refer to Lextek web site for specific mounting details and drawings at <https://leotek.com/lighting-library/>
- Specify MV (120-277V) or HV (347-480V).

LEOTEK®

GreenCobra™ Jr. LED Streetlight
GCJ J-Series Specification Data Sheet

Performance Data: 3000K (30K)

All data nominal. IES files for all CCTs available at leotek.com.

Product	LED Code	Output Code	System Wattage (W)	Delivered Lumens (lm)¹	Efficacy (lm/W)	Field Adjustable Output Range
GCJ1	30J	025	17	2533	149	↕
		040	27	4058	152	
		045	30	4560	152	
		050	34	5223	154	
		055	37	5550	150	
GCJ2	30J	065	44	6425	146	↕
		070	49	7062	145	
		075	54	7722	143	
		080	58	8236	142	
		090	64	8960	140	
GCJ3	30J	095	67	9380	140	↕
		105	70	10490	150	
		115	80	11637	145	
		125	87	12428	143	
		135	100	13730	137	
GCJ4	30J	135	100	13730	137	↕
		145	110	14988	157	
		120	80	12207	153	
		130	87	13047	150	
		145	100	14399	144	

Notes:

- Nominal lumens. Normal tolerance ± 10% due to factors including distribution type, LED bin variance, and ambient temperatures.
- Maximum LED drive current is 500mA.

Performance Data: 4000K (40K) and 5000K (50K)

All data nominal. IES files for all CCTs available at leotek.com.

Product	LED Code	Output Code	System Wattage (W)	Delivered Lumens (lm)¹	Efficacy (lm/W)	Field Adjustable Output Range
GCJ1	30J	025	17	2669	157	↕
		045	27	4299	161	
		050	30	4830	161	
		055	34	5532	163	
		060	37	5883	159	
GCJ2	30J	070	44	6864	156	↕
		075	49	7256	149	
		080	54	7992	148	
		085	58	8468	146	
		090	64	9216	144	
GCJ3	30J	095	67	9648	144	↕
		110	70	10988	157	
		120	80	12207	153	
		130	87	13047	150	
		145	100	14399	144	
GCJ4	30J	145	100	14399	144	↕
		155	110	15657	150	
		125	87	13047	150	
		135	94	13307	144	
		145	100	14399	144	

Notes:

- Nominal lumens. Normal tolerance ± 10% due to factors including distribution type, LED bin variance, and ambient temperatures.
- Maximum LED drive current is 500mA.


©2024 LEOTEK Electronics USA. GCJ4_J-Series_Specification Sheet_31-January-2024. Specifications subject to change without notice.

Page 4 of 7

2 PUBLIC LUMINAIRE DETAIL
SL2 NOT TO SCALE

LEOTEK®

GreenCobra™ Jr. LED Streetlight
GCJ J-Series Specification Data Sheet

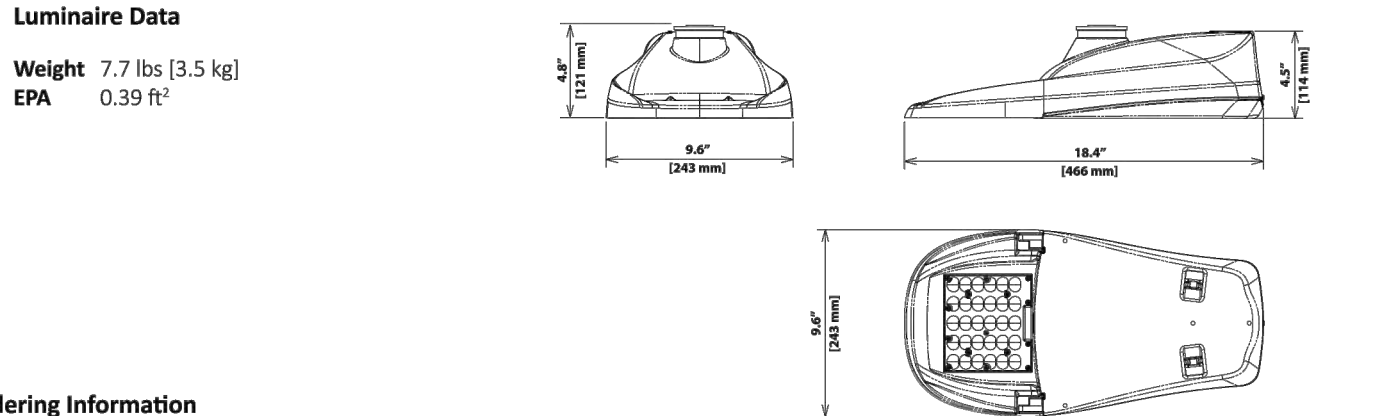

Ordering Information

Sample Catalog No. GCJ1-30J-MV-40K-2R-GY-05S-PCR7-WL

GCJ1	30J	MV	40K	4	GY	050	PCR7-WL
Model*	LED Code	Voltage	Color Temperature	Distribution	Finish*	Output Code*	Options
GCJ1*	30J	MV 120-277V	22K 2200K	2R Type 2	GY Gray	Refer to page 3 and 4 to select the output code.	FOC ¹ Fixed Output Code LPCR ² Less Photocontrol Receptacle ANSI 7-wire Photocontrol Receptacle Control Ready 7-wire PC Receptacle
GCJ2*		HV 347-480V	27K 2700K	3R Type 3R	DB Dark Bronze		MSL3 Motion Sensor, L3 Lens MSL7 Motion Sensor, L7 Lens Utility Wattage Label 4-Bolt Mounting Bracket RWG Rubber Wildlife Guard SWTB Straight Wire Terminal Block BBL Bubble Level DSC Door Safety Cable CF Coastal Paint Finish SP2 ³ Extreme Surge Protection, 20KV/10KA, Fail-to-on LSSP2 ³ Extreme Surge Protection, Fail-to-off, 20KV/10KA Rating
GCJ3*			30K 3000K	4 Type 3F	BK Black		
GCJ4*			40K 4000K	5 Type 5			
			50K 5000K				

* Refer to performance data table on page 3, 4 for specific model with corresponding output code

Notes:

- Gray, Black, and Dark Bronze standard. Consult factory for other finishes. See page 2 for IAL codes of Standard finishes.
- Specified output code is the factory set lumen performance. Refer to performance data table on page 3, 4 of this spec sheet.
- Field adjustable output selector enables future to be changed in the field to adjust light output for local conditions (not available with Fixed Output Code, FOC) or PCR7-CK option. Consult factory if wattage limits require a special drive current.
- Non-field adjustable, fixed output code. Specify required output code. Not available with PCR7-CK option.
- Includes output selector that enables field adjustability of light levels. Includes connectors to allow easy upgrade of wireless dimming via PCR7. Wireless node by others.
- Control ready wired at factory for wireless node dimming (node by others). Output selector not included in the future. Not able to adjust above specified output code.
- Specify the CF Option for coastal installation. See warranty for details.
- Standard surge protection, 10KV/5KA, fail-to-on, meets enhanced surge protection based on ANSI 136.25-2013 3-part test.
- Flush mounted house side shield. Shield cuts light off at 1 mounting height behind luminaire. Gray frame with black louvers.
- Flush mounted cut-de-sac shield. Shield cuts light off at 1 mounting height behind luminaire and 2 times the mounting height on either side of luminaire. Gray frame with black louvers.
- Flush mounted front side shield cuts light off at approximately 15x mounting height in front of luminaire (street side). Gray frame with black louvers.
- Specify Color (GY, DB, BK). Refer to Lextek web site for specific mounting details and drawings at <https://leotek.com/lighting-library/>
- Specify MV (120-277V) or HV (347-480V).

LEOTEK®

GreenCobra™ Jr. LED Streetlight
GCJ J-Series Specification Data Sheet

Performance Data: 3000K (30K)

All data nominal. IES files for all CCTs available at leotek.com.

Product	LED Code	Output Code	System Wattage (W)	Delivered Lumens (lm)¹	Efficacy (lm/W)	Field Adjustable Output Range
GCJ1	30J	025	17	2533	149	↕
		040	27	4058	152	
		045	30	4560	152	
		050	34	5223	154	
		055	37	5550	150	
GCJ2	30J	065	44	6425	146	↕
		070	49	7062	145	
		075	54	7722	143	
		080	58	8236	142	
		090	64	8960	140	
GCJ3	30J	095	67	9380	140	↕
		105	70	10490	150	
		115	80	11637	145	
		125	87	12428	143	
		135	100	13730	137	
GCJ4	30J	135	100	13730	137	↕
		145	110	14988	157	
		120	80	12207	153	
		130	87	13047	150	
		145	100	14399	144	

Notes:

- Nominal lumens. Normal tolerance ± 10% due to factors including distribution type, LED bin variance, and ambient temperatures.
- Maximum LED drive current is 500mA.

Performance Data: 4000K (40K) and 5000K (50K)

All data nominal. IES files for all CCTs available at leotek.com.

Product	LED Code	Output Code	System Wattage (W)	Delivered Lumens (lm)¹	Efficacy (lm/W)	Field Adjustable Output Range
GCJ1	30J	025	17	2669	157	↕
		045	27	4299	161	
		050	30	4830	161	
		055	34	5532	163	
		060	37	5883	159	
GCJ2	30J	070	44	6864	156	↕
		075	49	7256	149	
		080	54	7992	148	
		085	58	8468	146	
		090	64	9216	144	
GCJ3	30J	095	67	9648	144	↕
		110	70	10988	157	
		120	80	12207	153	
		130	87	13047	150	
		145	100	14399	144	
GCJ4	30J	145	100	14399	144	↕
		155	110	15657	150	
		125	87	13047	150	
		135	94	13307	144	
		145	100	14399	144	

Notes:

- Nominal lumens. Normal tolerance ± 10% due to factors including distribution type, LED bin variance, and ambient temperatures.
- Maximum LED drive current is 500mA.

©2024 LEOTEK Electronics USA. GCJ4_J-Series_Specification Sheet_31-January-2024. Specifications subject to change without notice.

Page 4 of 7



3 PUBLIC LUMINAIRE DETAIL
SL2 NOT TO SCALE

VOLTAGE DROP CALCULATIONS

LOCATION	DISTANCE	LOAD		VOLTAGE 120/240	WIRE SIZE	% VOLTAGE DROP	CIRCUIT #
		WATT	VOLT/AMP				



MATCH LINE SEE SHEET SL4

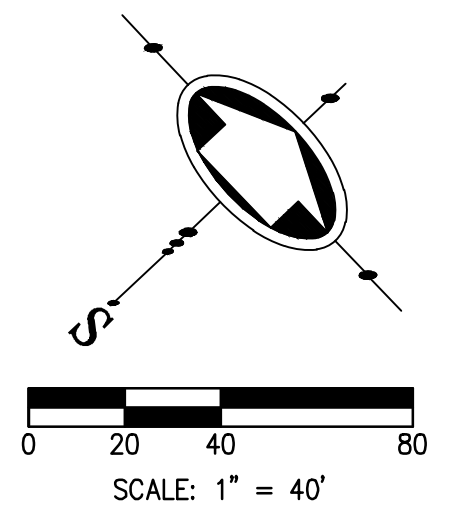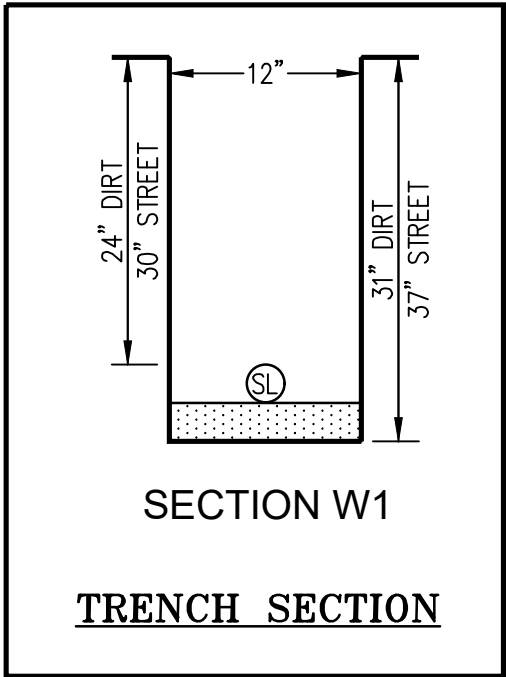

FOR REVIEW ONLY

813 First Street
Brentwood, CA 94513
(925) 240-2595
(925) 240-7013 fax
www.tarrar.com


TARRAR
UTILITY  CONSULTANTS


- Planning
 - Design
 - Estimating
 - Joint Trench
 - Street Lighting
 - Fiber Optic
 - T-24
 - PG&E Gas Design
 - PG&E Elec Design
 - M.E.P. Design
 - Cost Analysis
 - Due Diligence

STREET LIGHTING SITE PLAN
LEGACY BUILDERS, INC
RIALTO PLACE
ANTIOCH CALIFORNIA


NO.	REVISIONS	BY	DATE

DATE: April 2024	DATE LAST WORKED ON: 5/3/2024
SCALE: 1" = 20'	DRAWN: HA
JOB NO.: 224054	CHECKED: ML
PRELIMINARY NOT FOR CONSTRUCTION	
INTENT TO CONSTRUCT	

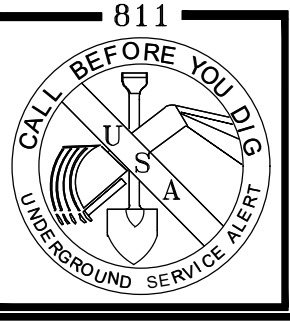


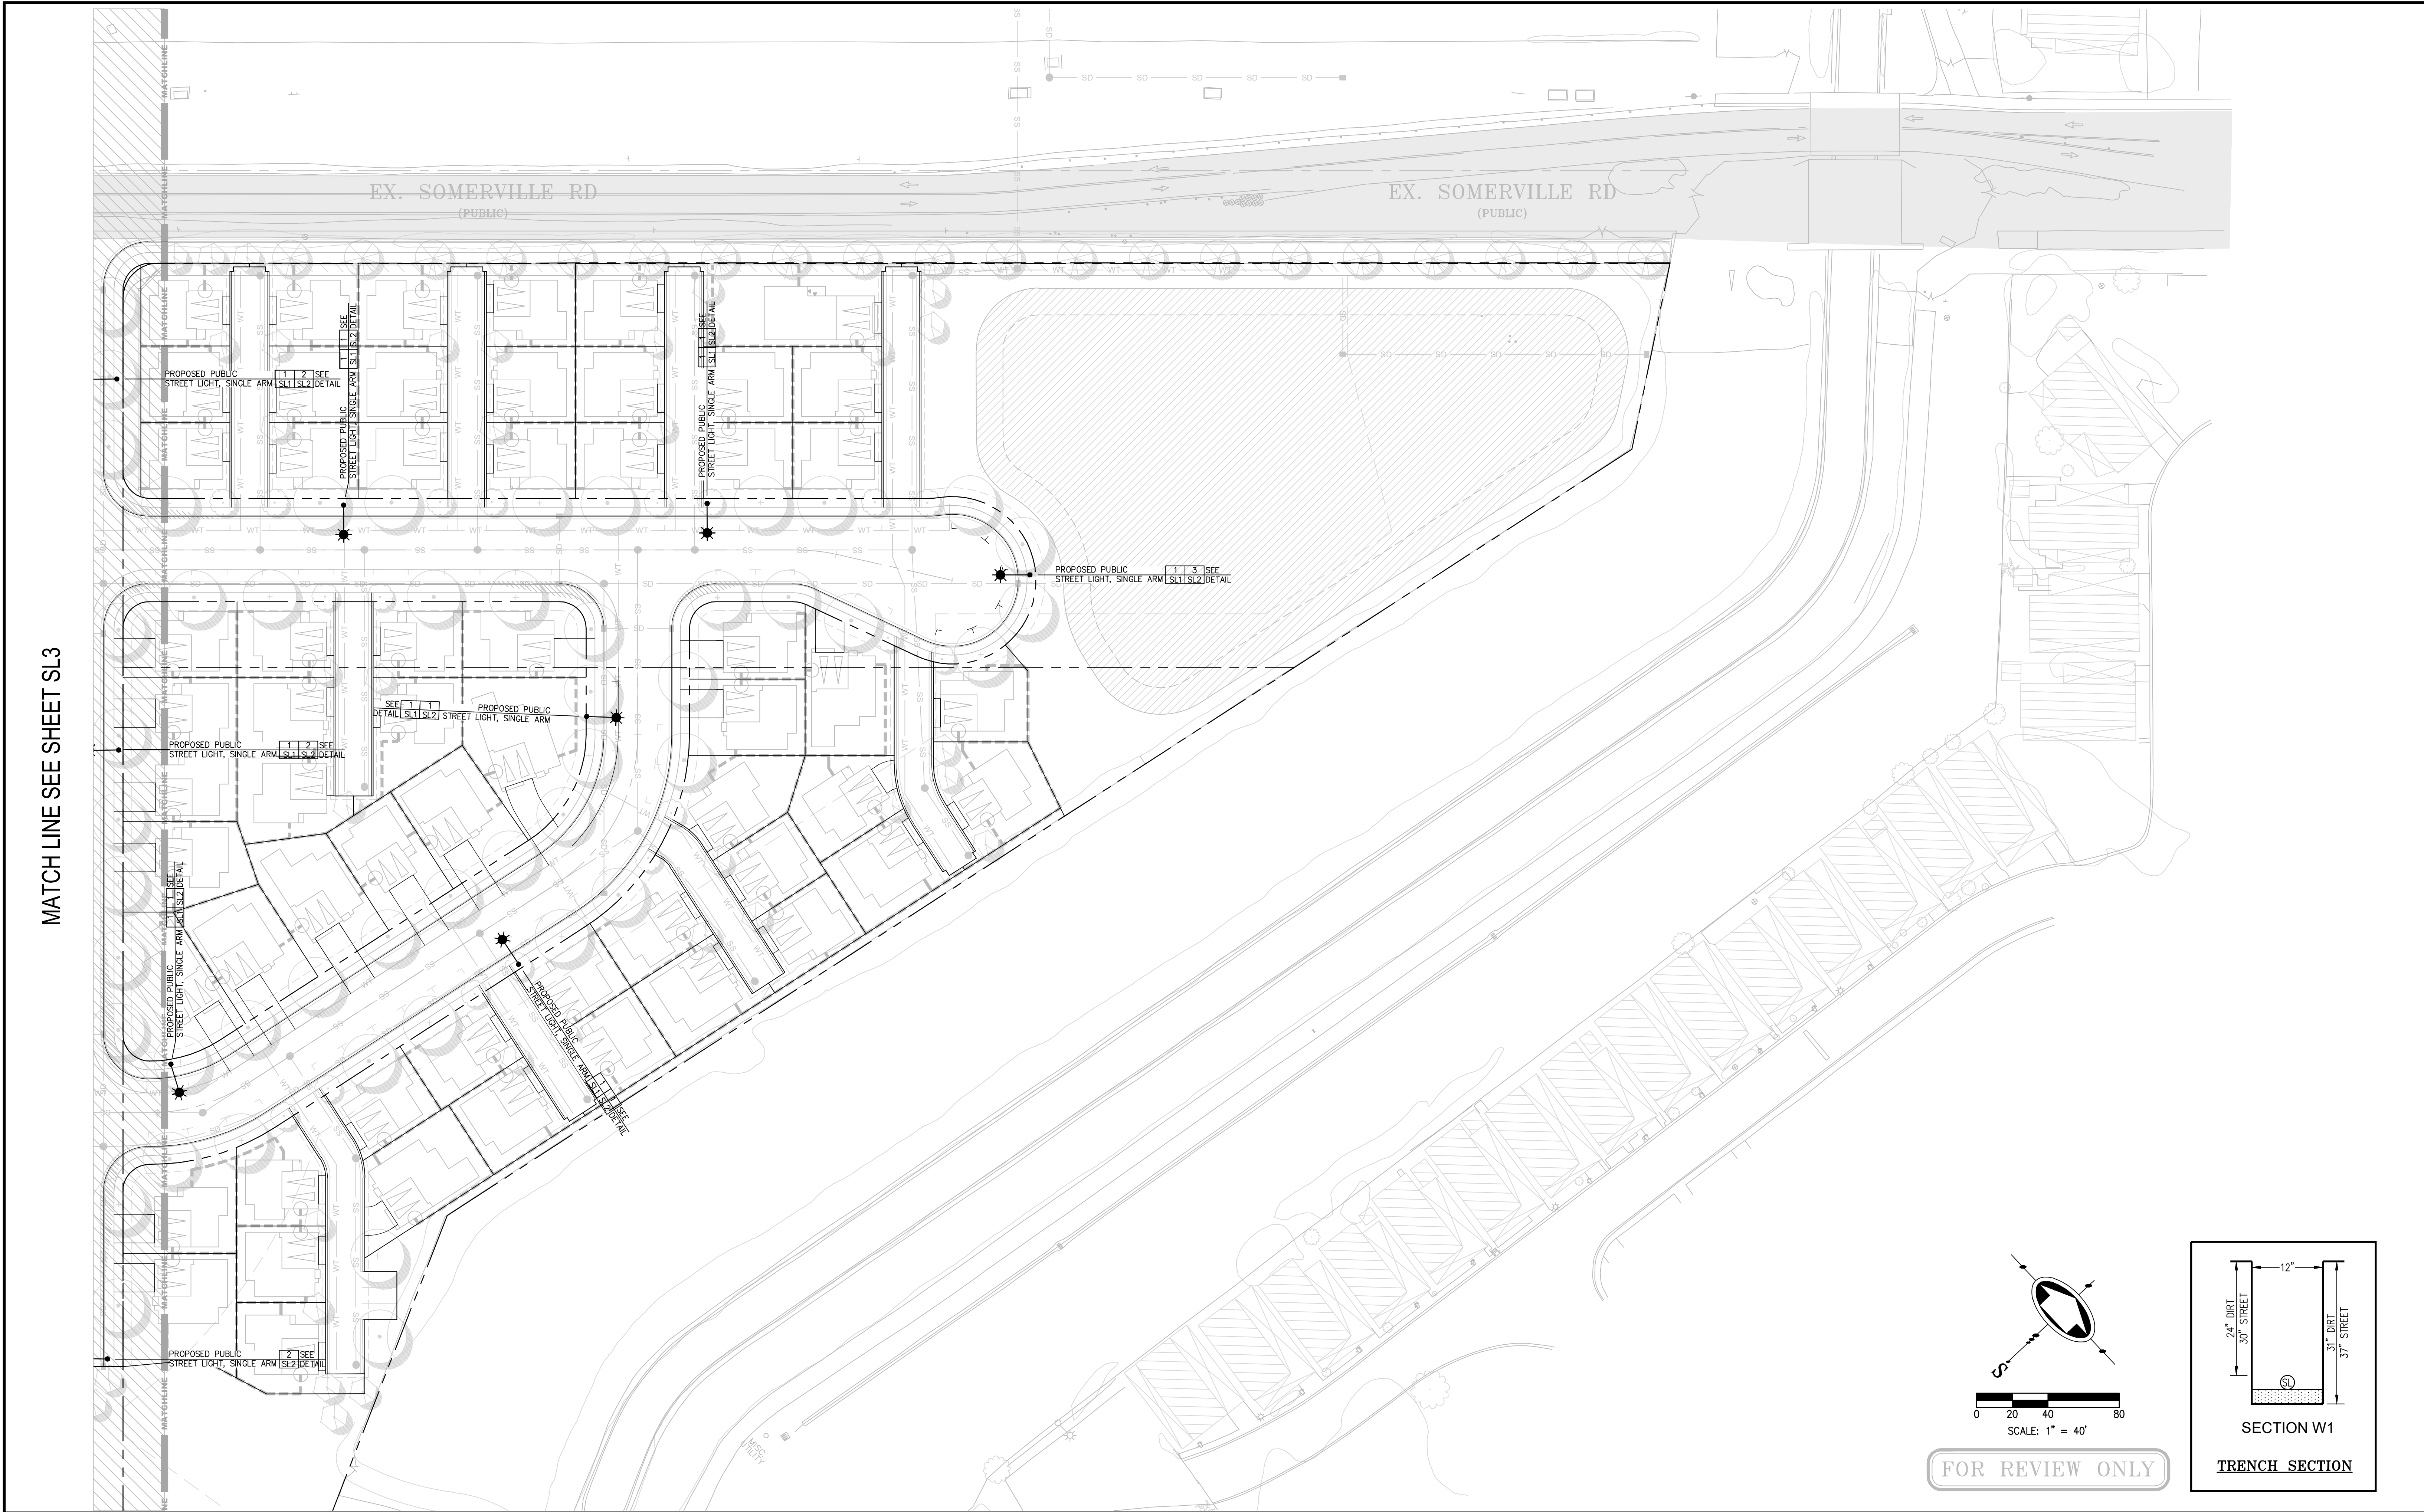

MATCH LINE SEE SHEET SL3

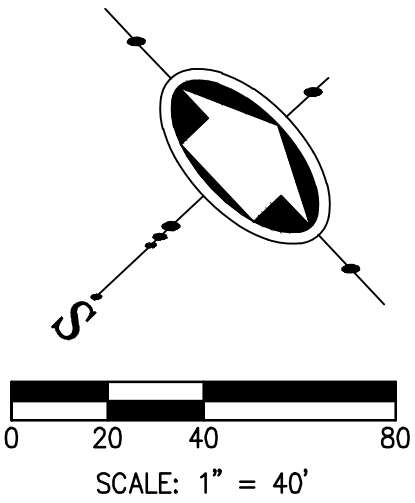

FOR REVIEW ONLY

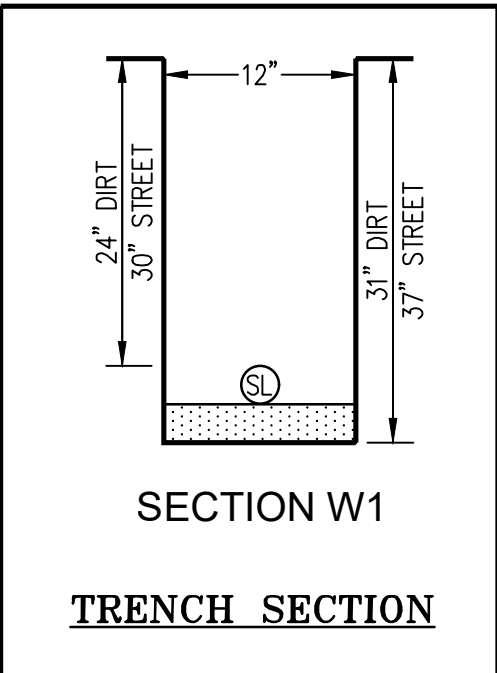

813 First Street
Brentwood, CA 94513
(925) 240-2595
(925) 240-7013 fax
www.tarrar.com

TARRAR
UTILITY CONSULTANTS

- Planning
- Design
- Estimating
- Joint Trench
- Street Lighting
- Fiber Optic
- T-24
- PG&E Gas Design
- PG&E Elec Design
- M. E. P. Design
- Cost Analysis
- Due Diligence

STREET LIGHTING SITE PLAN
LEGACY BUILDERS. INC
RIALTO PLACE
ANTIOCH CALIFORNIA

NO.	REVISIONS	BY	DATE

DATE: April 2024

DATE LAST WORKED ON: 5/3/2024

SCALE: 1" = 20'

DRAWN: HA

CHECKED: ML



JOB NO.: 224054

PRELIMINARY
NOT FOR CONSTRUCTION

INTENT TO CONSTRUCT



SHEET
SL4
OF
SL4
SHEETS

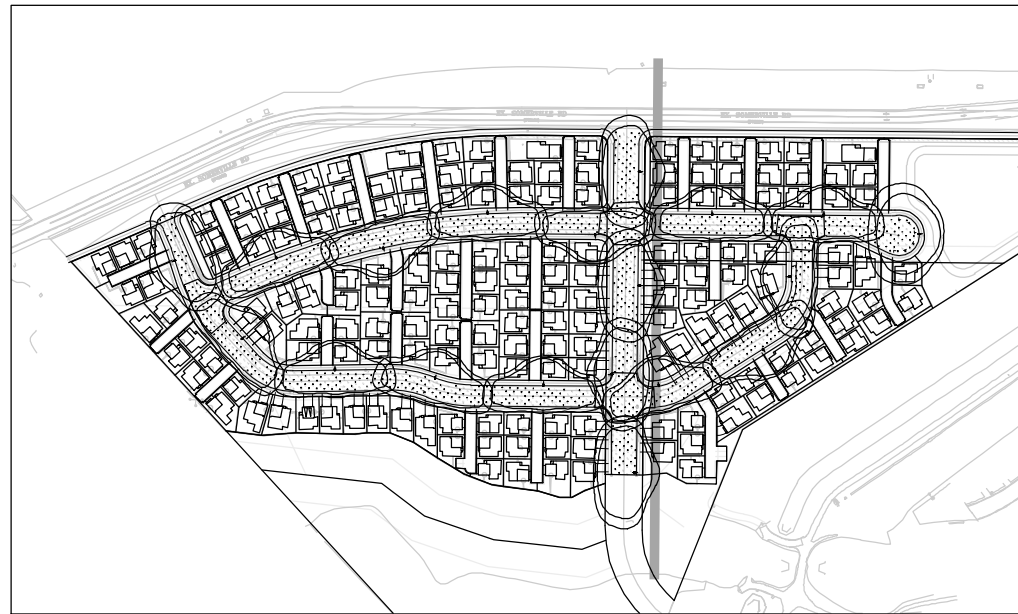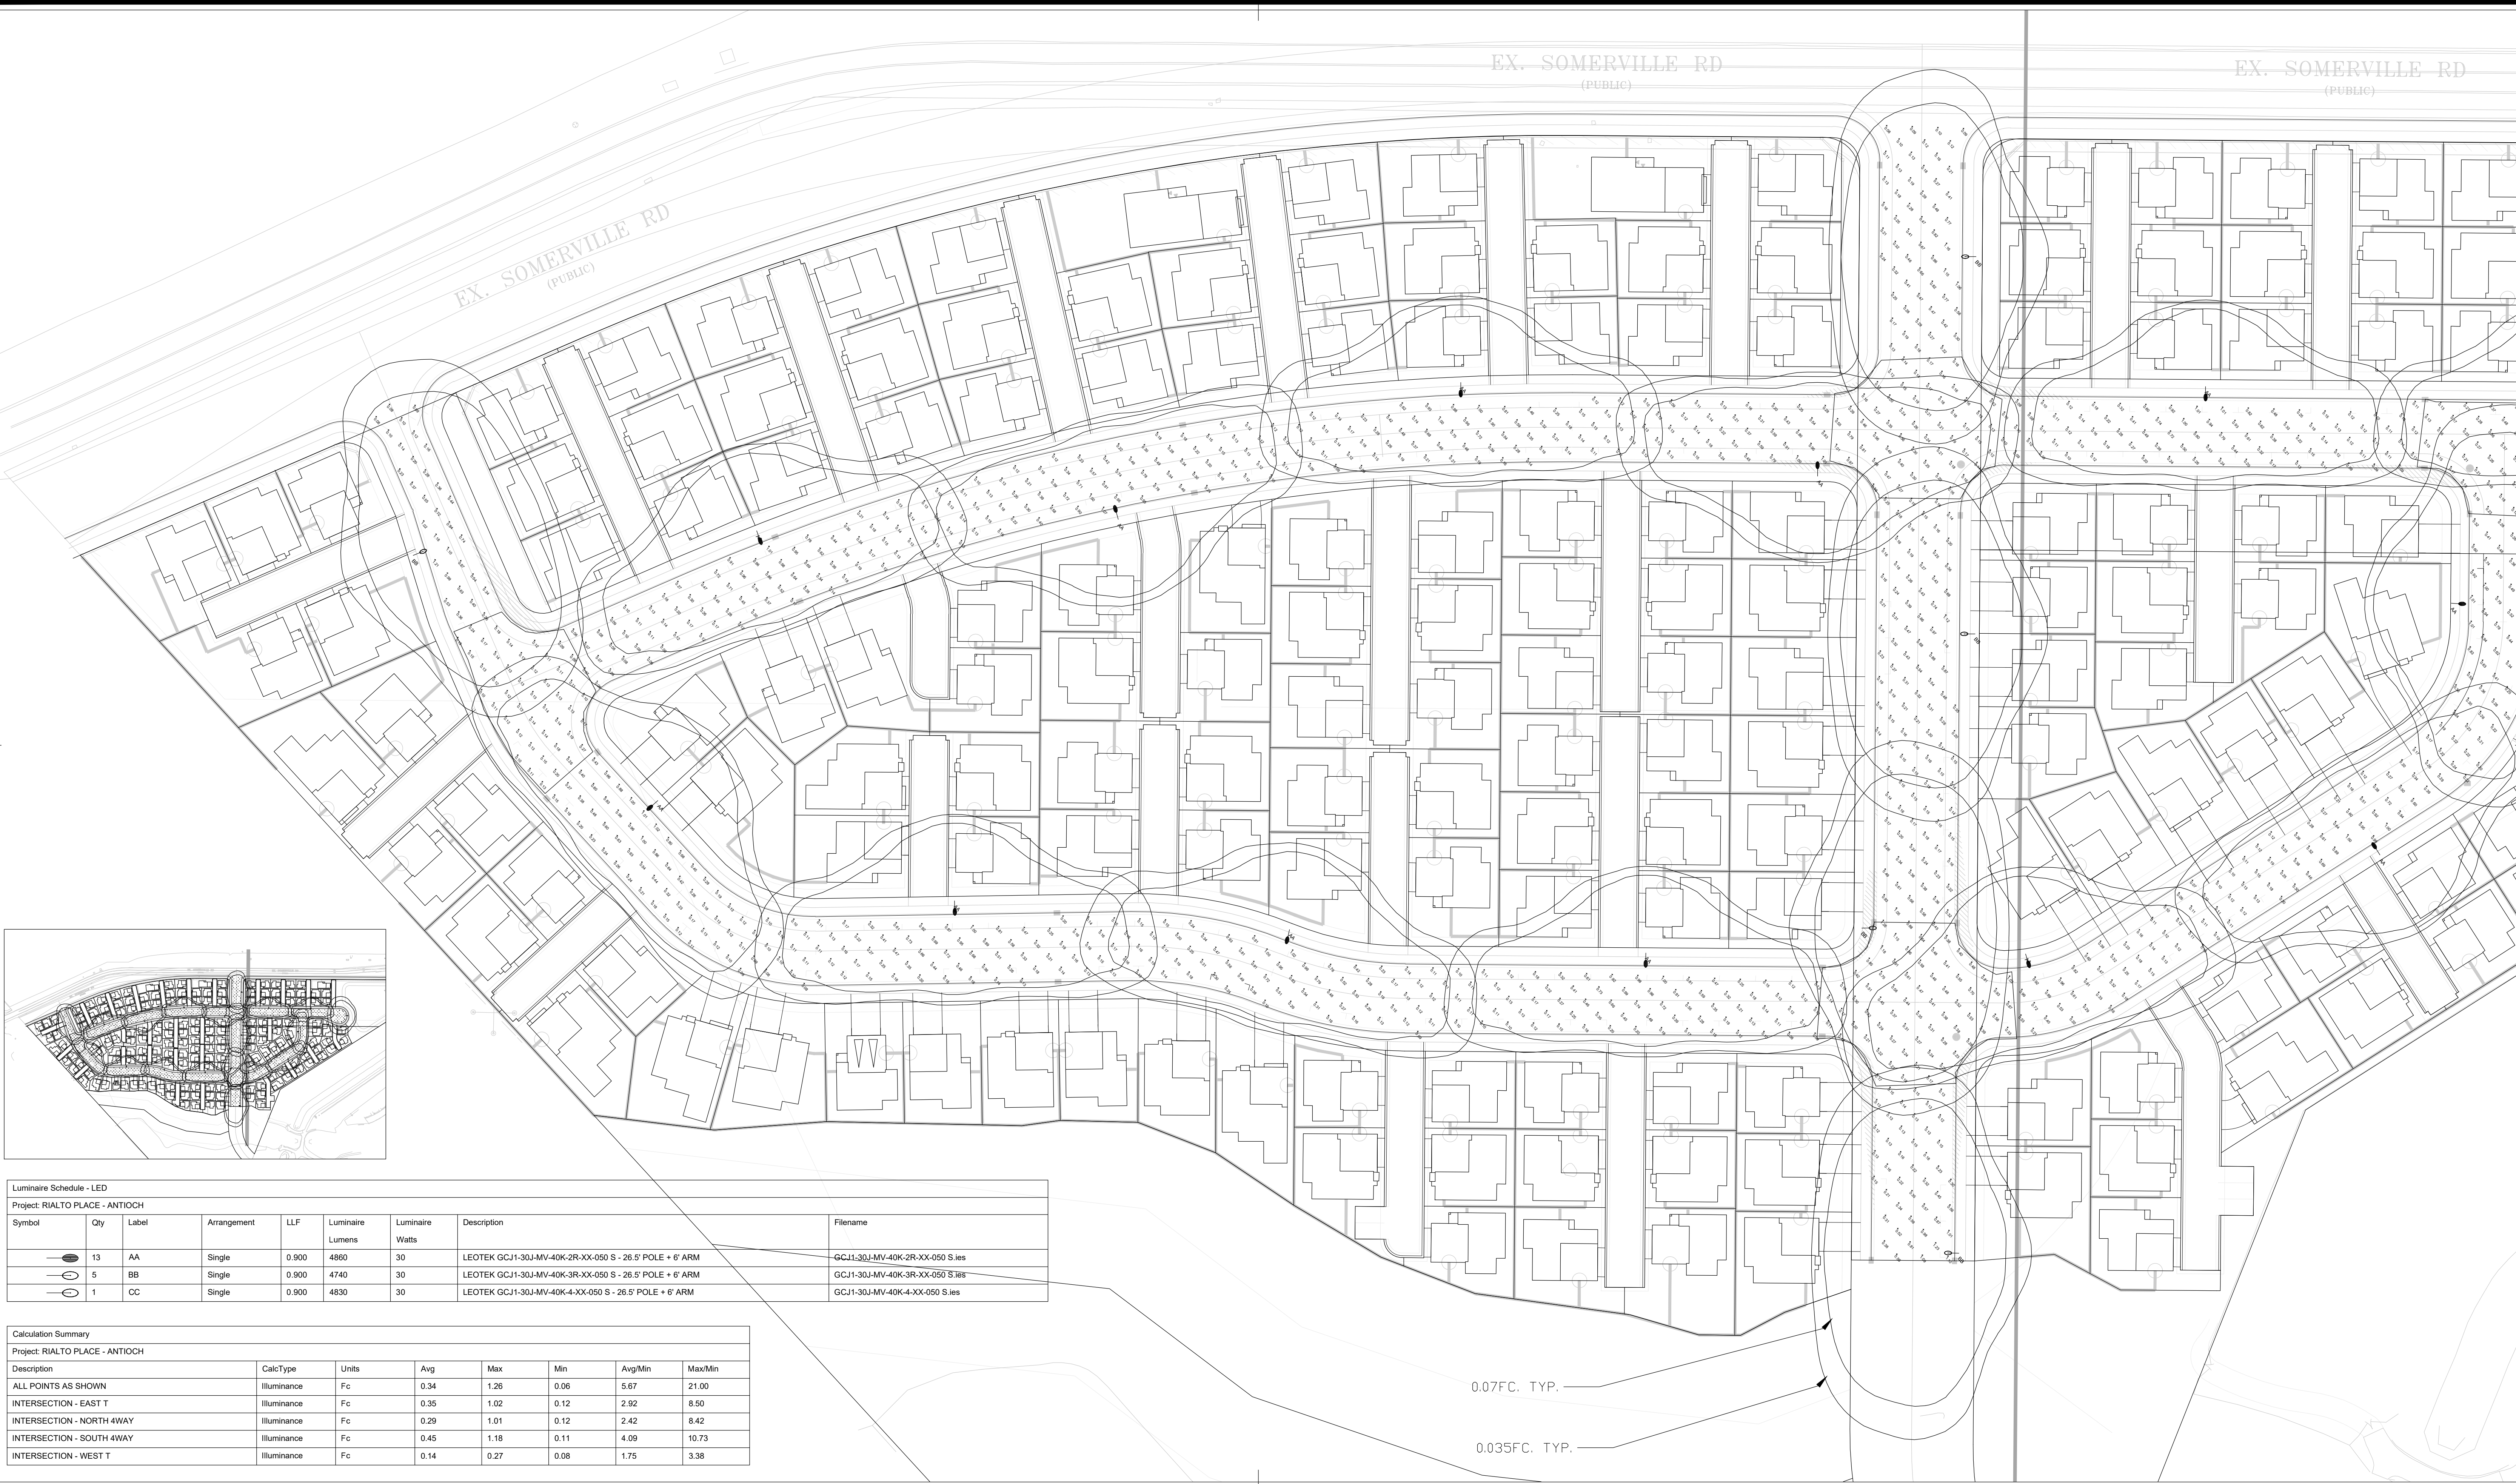

Luminaire Schedule - LED								
Project: RIALTO PLACE - ANTIOCH								
Symbol	Qty	Label	Arrangement	LLF	Luminaire Lumens	Luminaire Watts	Description	Filename
	13	AA	Single	0.900	4860	30	LEOTEK GCJ1-30J-MV-40K-2R-XX-050 S - 26.5' POLE + 6' ARM	GCJ1-30J-MV-40K-2R-XX-050 S.ies
	5	BB	Single	0.900	4740	30	LEOTEK GCJ1-30J-MV-40K-3R-XX-050 S - 26.5' POLE + 6' ARM	GCJ1-30J-MV-40K-3R-XX-050 S.ies
	1	CC	Single	0.900	4830	30	LEOTEK GCJ1-30J-MV-40K-4-XX-050 S - 26.5' POLE + 6' ARM	GCJ1-30J-MV-40K-4-XX-050 S.ies

Calculation Summary								
Project: RIALTO PLACE - ANTIOCH								
Description	CalcType	Units	Avg	Max	Min	Avg/Min	Max/Min	
ALL POINTS AS SHOWN	Illuminance	Fc	0.34	1.26	0.06	5.67	21.00	
INTERSECTION - EAST T	Illuminance	Fc	0.35	1.02	0.12	2.92	8.50	
INTERSECTION - NORTH 4WAY	Illuminance	Fc	0.29	1.01	0.12	2.42	8.42	
INTERSECTION - SOUTH 4WAY	Illuminance	Fc	0.45	1.18	0.11	4.09	10.73	
INTERSECTION - WEST T	Illuminance	Fc	0.14	0.27	0.08	1.75	3.38	

0.07FC. TYP.


0.035FC. TYP.

ALL VALUES SHOWN ARE MAINTAINED HORIZONTAL FOOTCANDLES AT GRADE

PHOTOMETRIC DATA USED AS INPUT FOR THESE CALCULATIONS IS BASED ON ESTABLISHED IES PROCEDURES AND PUBLISHED LAMP, RATINGS, FIELD PERFORMANCE WILL DEPEND ON ACTUAL LAMP, BALLAST, ELECTRICAL, AND SITE CHARACTERISTICS.

Calculations have been performed according to IES standards and good practice. Some differences between measured values and calculated results may occur due to tolerances in calculation methods, testing procedures, component performance, measurement techniques and field conditions such as voltage and temperature variations. Input data used to generate the attached calculations such as room dimensions, reflectances, furniture and architectural elements significantly affect the lighting calculations. If the real environment conditions do not match the input data, differences will occur between measured values and calculated values.

**Associated Lighting Representatives, Inc.**

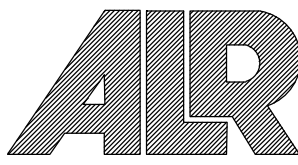

ASSOCIATED LIGHTING REPRESENTATIVES, INC
7777 PARDEE LANE
P.O. BOX 2265
OAKLAND, CA 94621
PHONE: (510) 638-0158 - FAX (510) 638-2908

REPORT FOR: TARRAR UTILITY CONSULTANTS
BY: APPLICATIONS ENGINEERING; RAMON ZAPATA
SALES REPRESENTATIVE: ALR; KRISTIAN REYES



AGI32 VERSION 21.2
AGI (C) 2024 LIGHTING ANALYSTS, INC.
10268 W. CENTENNIAL ROAD, SUITE 202
LITTLETON, CO 80127

PROJECT DESCRIPTION

RIALTO PLACE
CITY OF ANTIOCH

DRAWING NO. / INPUT FILE


22835REY.DWG / 22835REY.A32

SCALE
1" = 40'

SHEET
1 OF 2

DATE
04.29.2024

REV
X

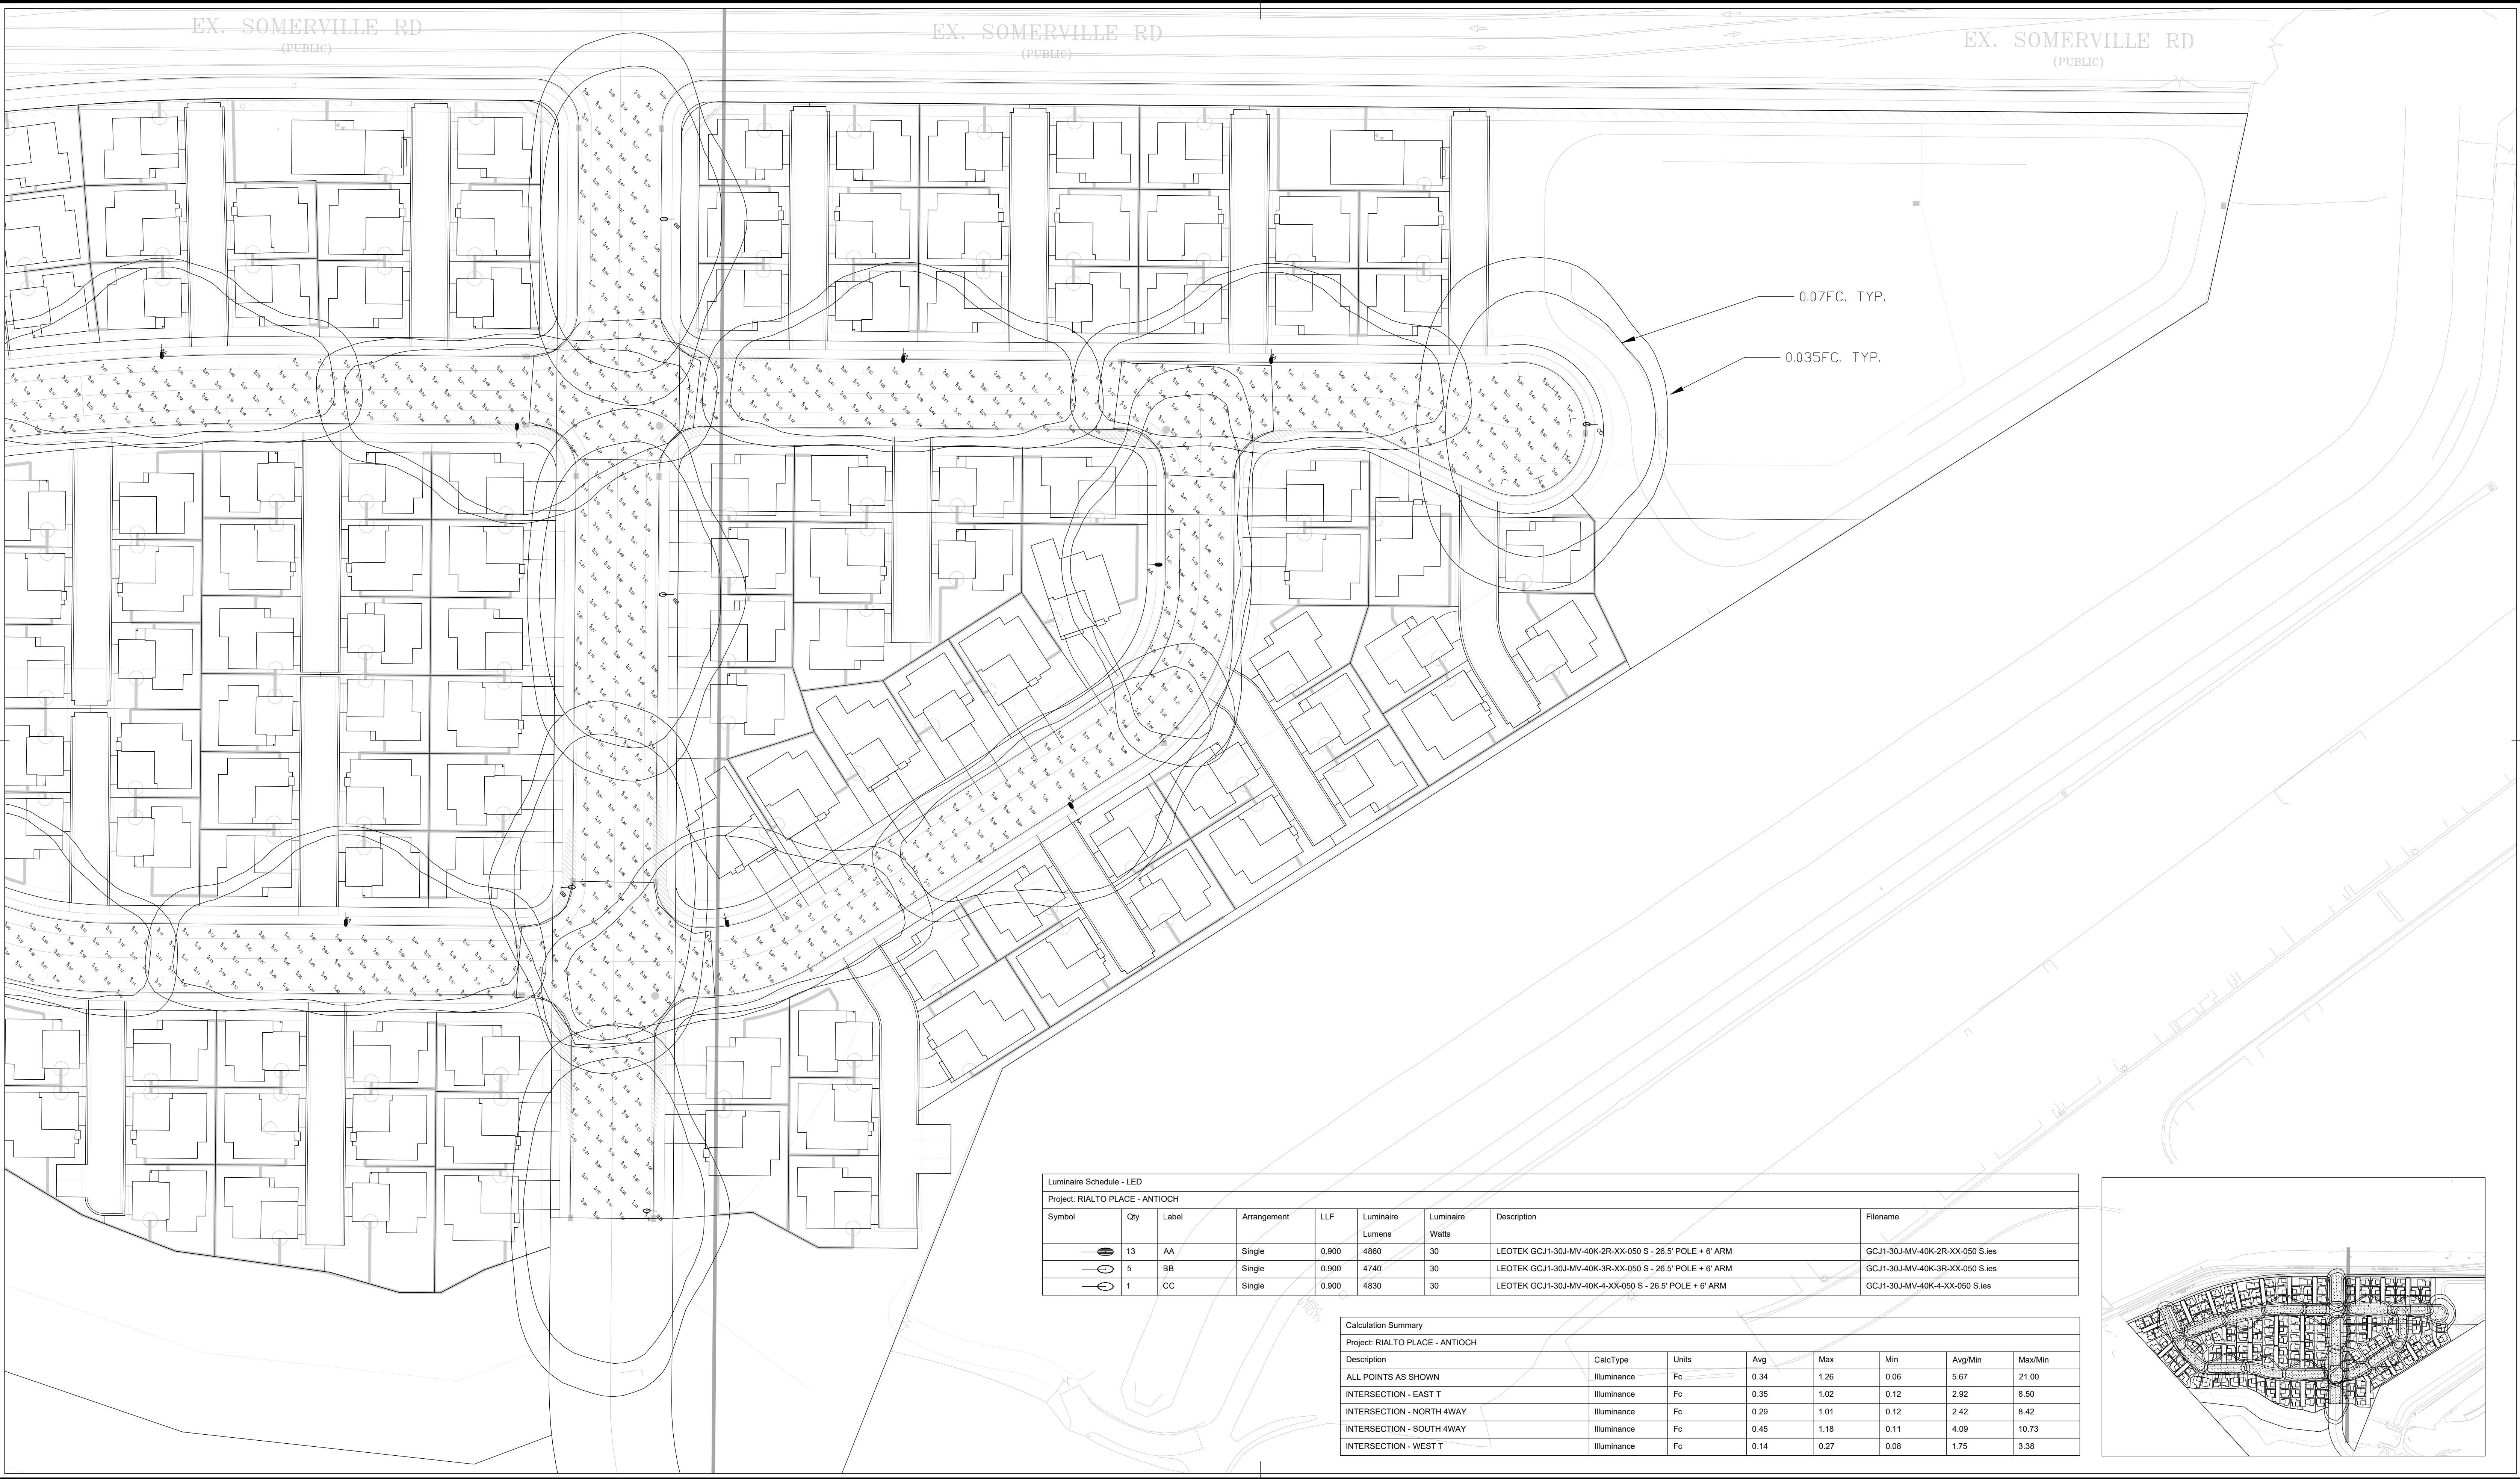

Luminaire Schedule - LED							
Project: RIALTO PLACE - ANTIOCH							
Symbol	Qty	Label	Arrangement	LLF	Luminaire Lumens	Luminaire Watts	Description
	13	AA	Single	0.900	4860	30	LEOTEK GCJ1-30J-MV-40K-2R-XX-050 S - 26.5' POLE + 6' ARM
	5	BB	Single	0.900	4740	30	LEOTEK GCJ1-30J-MV-40K-3R-XX-050 S - 26.5' POLE + 6' ARM
	1	CC	Single	0.900	4830	30	LEOTEK GCJ1-30J-MV-40K-4-XX-050 S - 26.5' POLE + 6' ARM
		Filename					
		GCJ1-30J-MV-40K-2R-XX-050 S.ies					
		GCJ1-30J-MV-40K-3R-XX-050 S.ies					
		GCJ1-30J-MV-40K-4-XX-050 S.ies					


Calculation Summary							
Project: RIALTO PLACE - ANTIOCH							
Description	CalcType	Units	Avg	Max	Min	Avg/Min	Max/Min
ALL POINTS AS SHOWN	Illuminance	Fc	0.34	1.26	0.06	5.67	21.00
INTERSECTION - EAST T	Illuminance	Fc	0.35	1.02	0.12	2.92	8.50
INTERSECTION - NORTH 4WAY	Illuminance	Fc	0.29	1.01	0.12	2.42	8.42
INTERSECTION - SOUTH 4WAY	Illuminance	Fc	0.45	1.18	0.11	4.09	10.73
INTERSECTION - WEST T	Illuminance	Fc	0.14	0.27	0.08	1.75	3.38



ALL VALUES SHOWN ARE MAINTAINED HORIZONTAL FOOTCANDLES AT GRADE

PHOTOMETRIC DATA USED AS INPUT FOR THESE CALCULATIONS IS BASED ON ESTABLISHED IES PROCEDURES AND PUBLISHED LAMP, RATINGS, FIELD PERFORMANCE WILL DEPEND ON ACTUAL LAMP, BALLAST, ELECTRICAL, AND SITE CHARACTERISTICS.

Calculations have been performed according to IES standards and good practice. Some differences between measured values and calculated results may occur due to tolerances in calculation methods, testing procedures, component performance, measurement techniques and field conditions such as voltage and temperature variations. Input data used to generate the attached calculations such as room dimensions, reflectances, furniture and architectural elements significantly affect the lighting calculations. If the real environment conditions do not match the input data, differences will occur between measured values and calculated values.

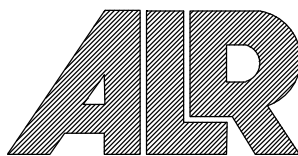

ASSOCIATED LIGHTING REPRESENTATIVES, INC
7777 PARDEE LANE
P.O. BOX 2265
OAKLAND, CA 94621
PHONE: (510) 638-0158 - FAX (510) 638-2908

REPORT FOR: TARRAR UTILITY CONSULTANTS
BY: APPLICATIONS ENGINEERING; RAMON ZAPATA
SALES REPRESENTATIVE: ALR; KRISTIAN REYES




AGI32 VERSION 21.2
AGI (C) 2024 LIGHTING ANALYSTS, INC.
10268 W. CENTENNIAL ROAD, SUITE 202
LITTLETON, CO 80127

PROJECT DESCRIPTION

RIALTO PLACE
CITY OF ANTIOCH

DRAWING NO. / INPUT FILE
22835REY.DWG / 22835REY.A32

SCALE	SHEET	DATE	REV
1" = 40'	2 OF 2	04.29.2024	X

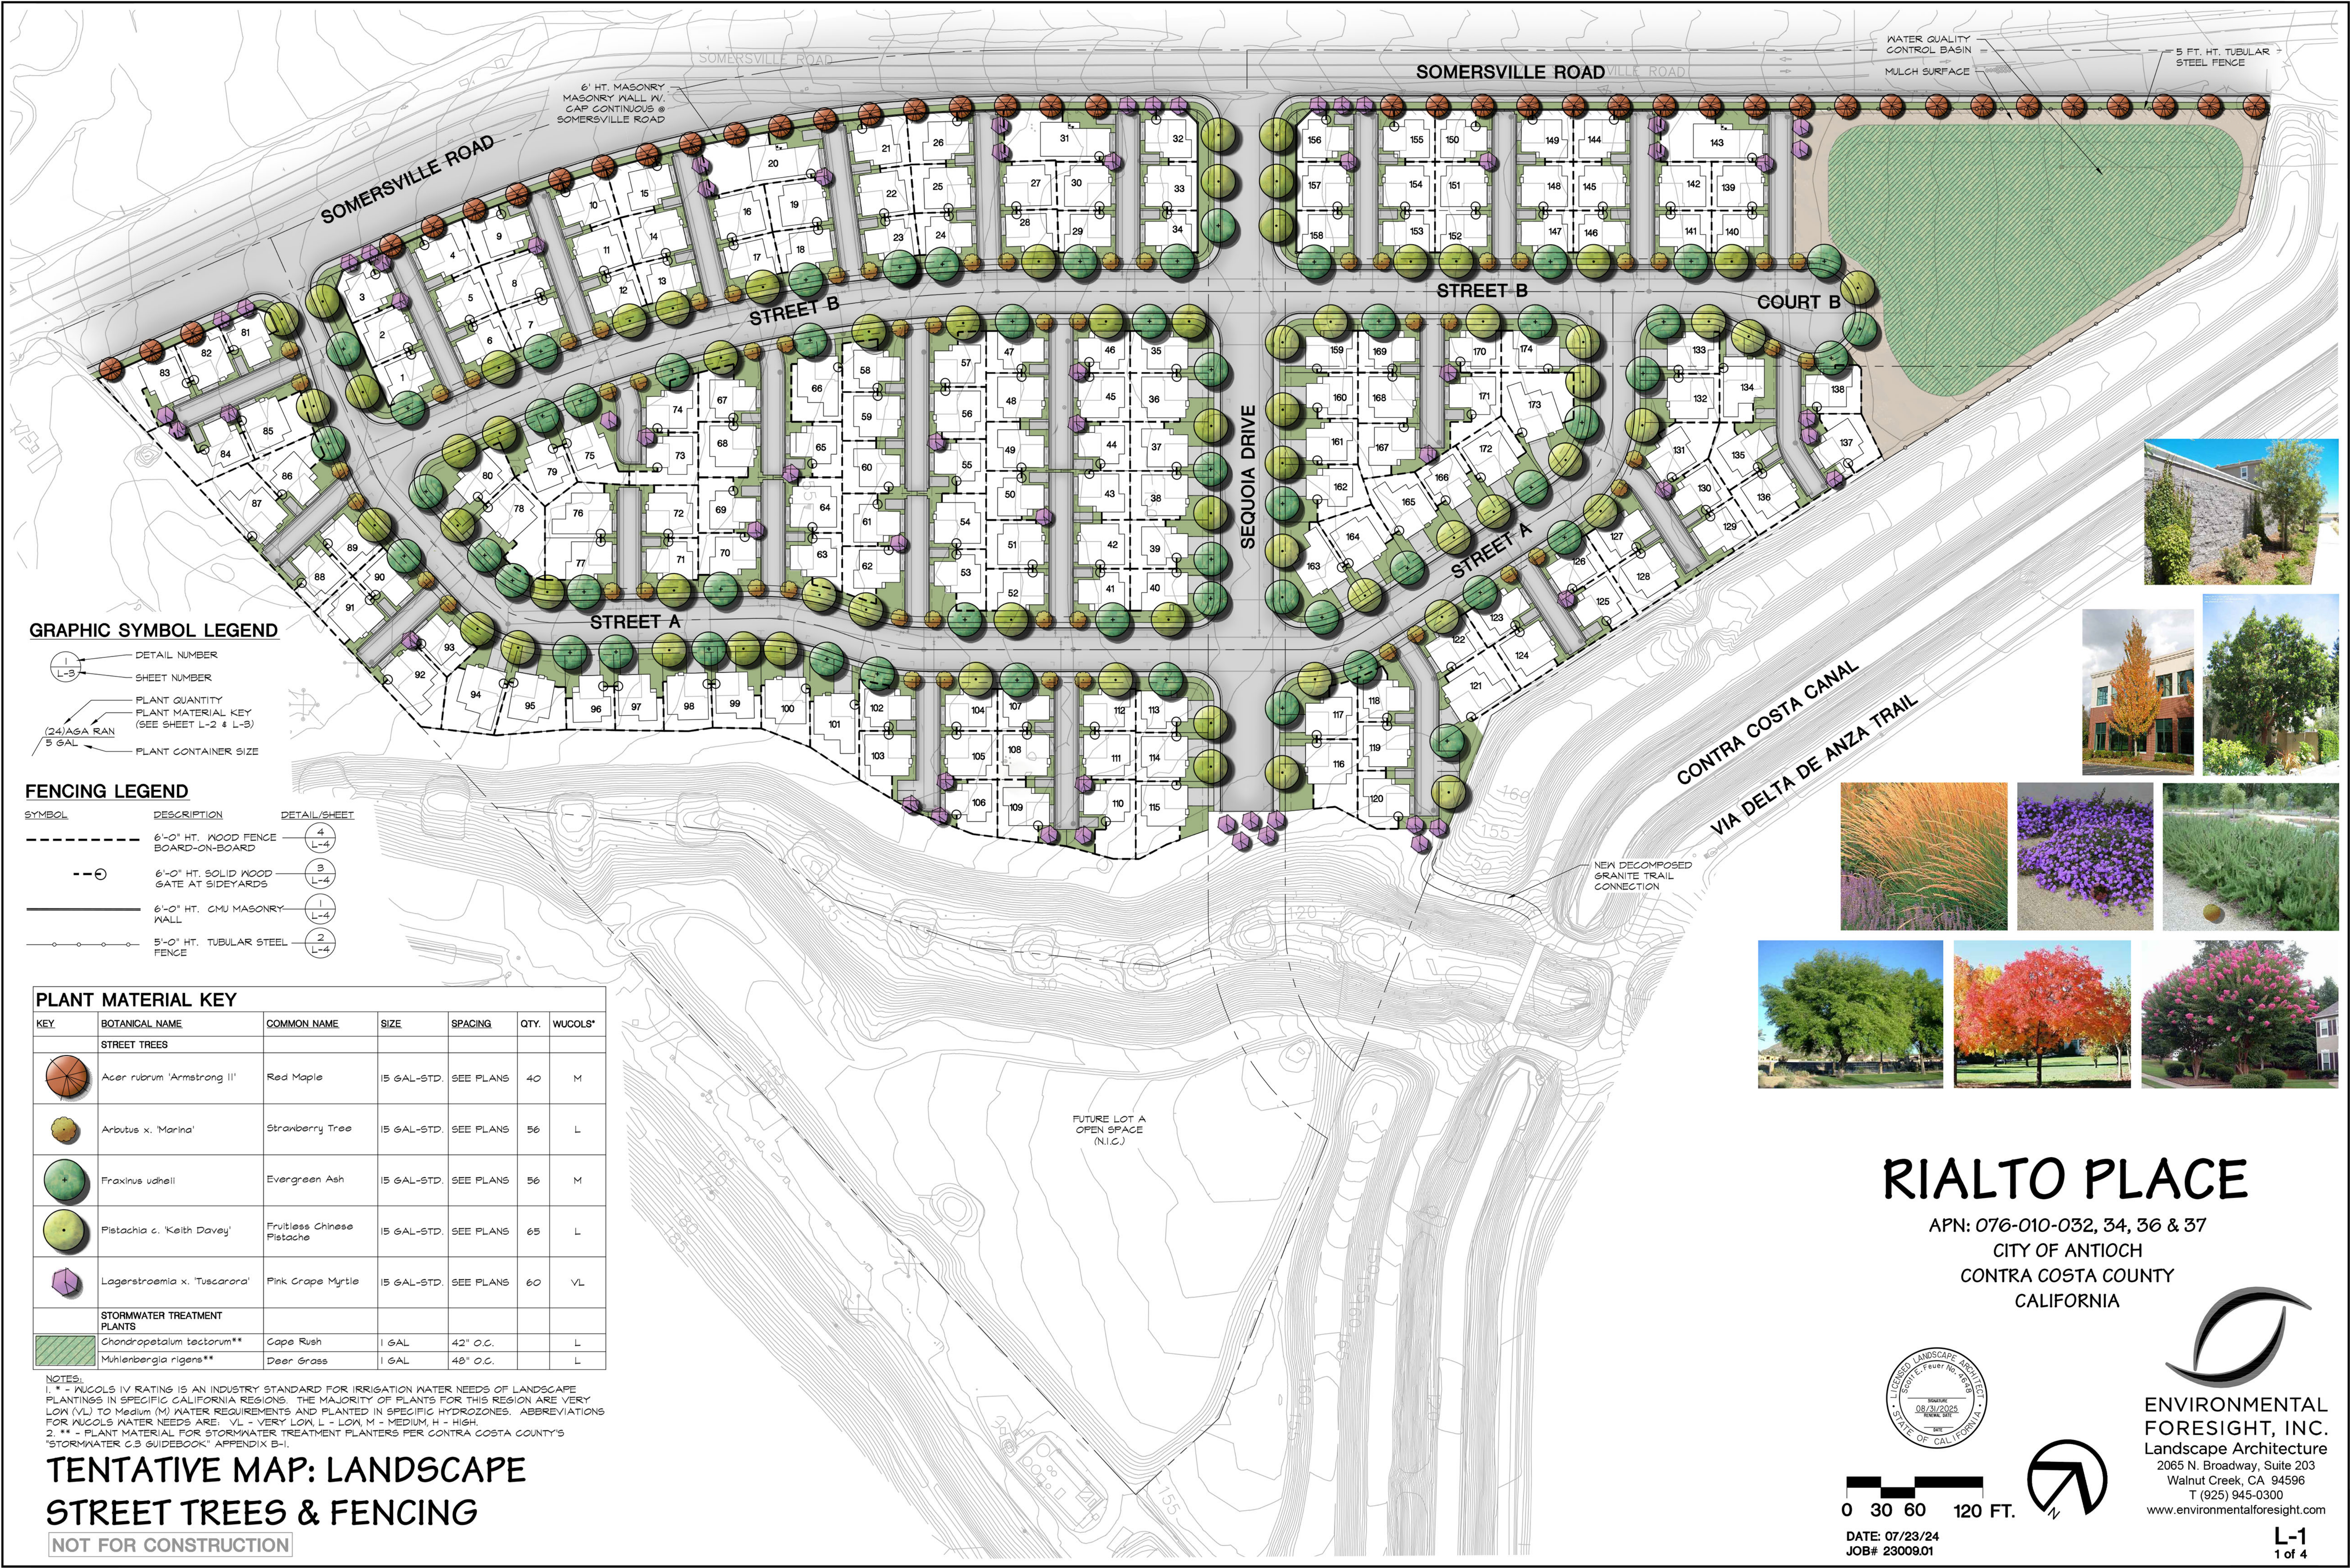

GRAPHIC SYMBOL LEGEND

- 1 - DETAIL NUMBER
- L-3 - SHEET NUMBER
- PLANT QUANTITY
- PLANT MATERIAL KEY (SEE SHEET L-2 & L-3)
- (24) ASA RAN 5 GAL - PLANT CONTAINER SIZE

FENCING LEGEND

- | SYMBOL | DESCRIPTION | DETAIL/SHEET |
|---------|--|--------------|
| --- | 6'-0" HT. WOOD FENCE BOARD-ON-BOARD | 4 L-4 |
| ---O--- | 6'-0" HT. SOLID WOOD GATE AT SIDEYARDS | 3 L-4 |
| --- | 6'-0" HT. CMU MASONRY WALL | 1 L-4 |
| ---O--- | 5'-0" HT. TUBULAR STEEL FENCE | 2 L-4 |

PLANT MATERIAL KEY

KEY	BOTANICAL NAME	COMMON NAME	SIZE	SPACING	QTY.	WUCOLS*
STREET TREES						
	Acer rubrum 'Armstrong II'	Red Maple	15 GAL-STD.	SEE PLANS	40	M
	Arbutus x. 'Marina'	Strawberry Tree	15 GAL-STD.	SEE PLANS	56	L
	Fraxinus udrhelli	Evergreen Ash	15 GAL-STD.	SEE PLANS	56	M
	Pistachia c. 'Keith Davey'	Fruitless Chinese Pistache	15 GAL-STD.	SEE PLANS	65	L
	Lagerstroemia x. 'Tuscarora'	Pink Grape Myrtle	15 GAL-STD.	SEE PLANS	60	VL
STORMWATER TREATMENT PLANTS						
	Chandropetalum tectorum**	Cape Rush	1 GAL	42" O.C.		L
	Muhlenbergia rigens**	Deer Grass	1 GAL	48" O.C.		L

NOTES:
1. * - WUCOLS IV RATING IS AN INDUSTRY STANDARD FOR IRRIGATION WATER NEEDS OF LANDSCAPE PLANTINGS IN SPECIFIC CALIFORNIA REGIONS. THE MAJORITY OF PLANTS FOR THIS REGION ARE VERY LOW (VL) TO MEDIUM (M) WATER REQUIREMENTS AND PLANTED IN SPECIFIC HYDROZONES. ABBREVIATIONS FOR WUCOLS WATER NEEDS ARE: VL - VERY LOW, L - LOW, M - MEDIUM, H - HIGH.
2. ** - PLANT MATERIAL FOR STORMWATER TREATMENT PLANTERS PER CONTRA COSTA COUNTY'S "STORMWATER C.B. GUIDEBOOK" APPENDIX B-1.

TENTATIVE MAP: LANDSCAPE
STREET TREES & FENCING

NOT FOR CONSTRUCTION



RIALTO PLACE

APN: 076-010-032, 34, 36 & 37
CITY OF ANTIOCH
CONTRA COSTA COUNTY
CALIFORNIA



ENVIRONMENTAL
FORESIGHT, INC.
Landscape Architecture
2065 N. Broadway, Suite 203
Walnut Creek, CA 94596
T (925) 945-0300
www.environmentalforesight.com




DATE: 07/23/24
JOB# 23009.01

P:\2023\23009_01\dwg\prelim\L-2-Prelim-RP.dwg, 7/23/2024 9:46:18 AM

TENTATIVE MAP: LANDSCAPE TYPICALS 4 & 6-PACK LOTS

NOT FOR CONSTRUCTION

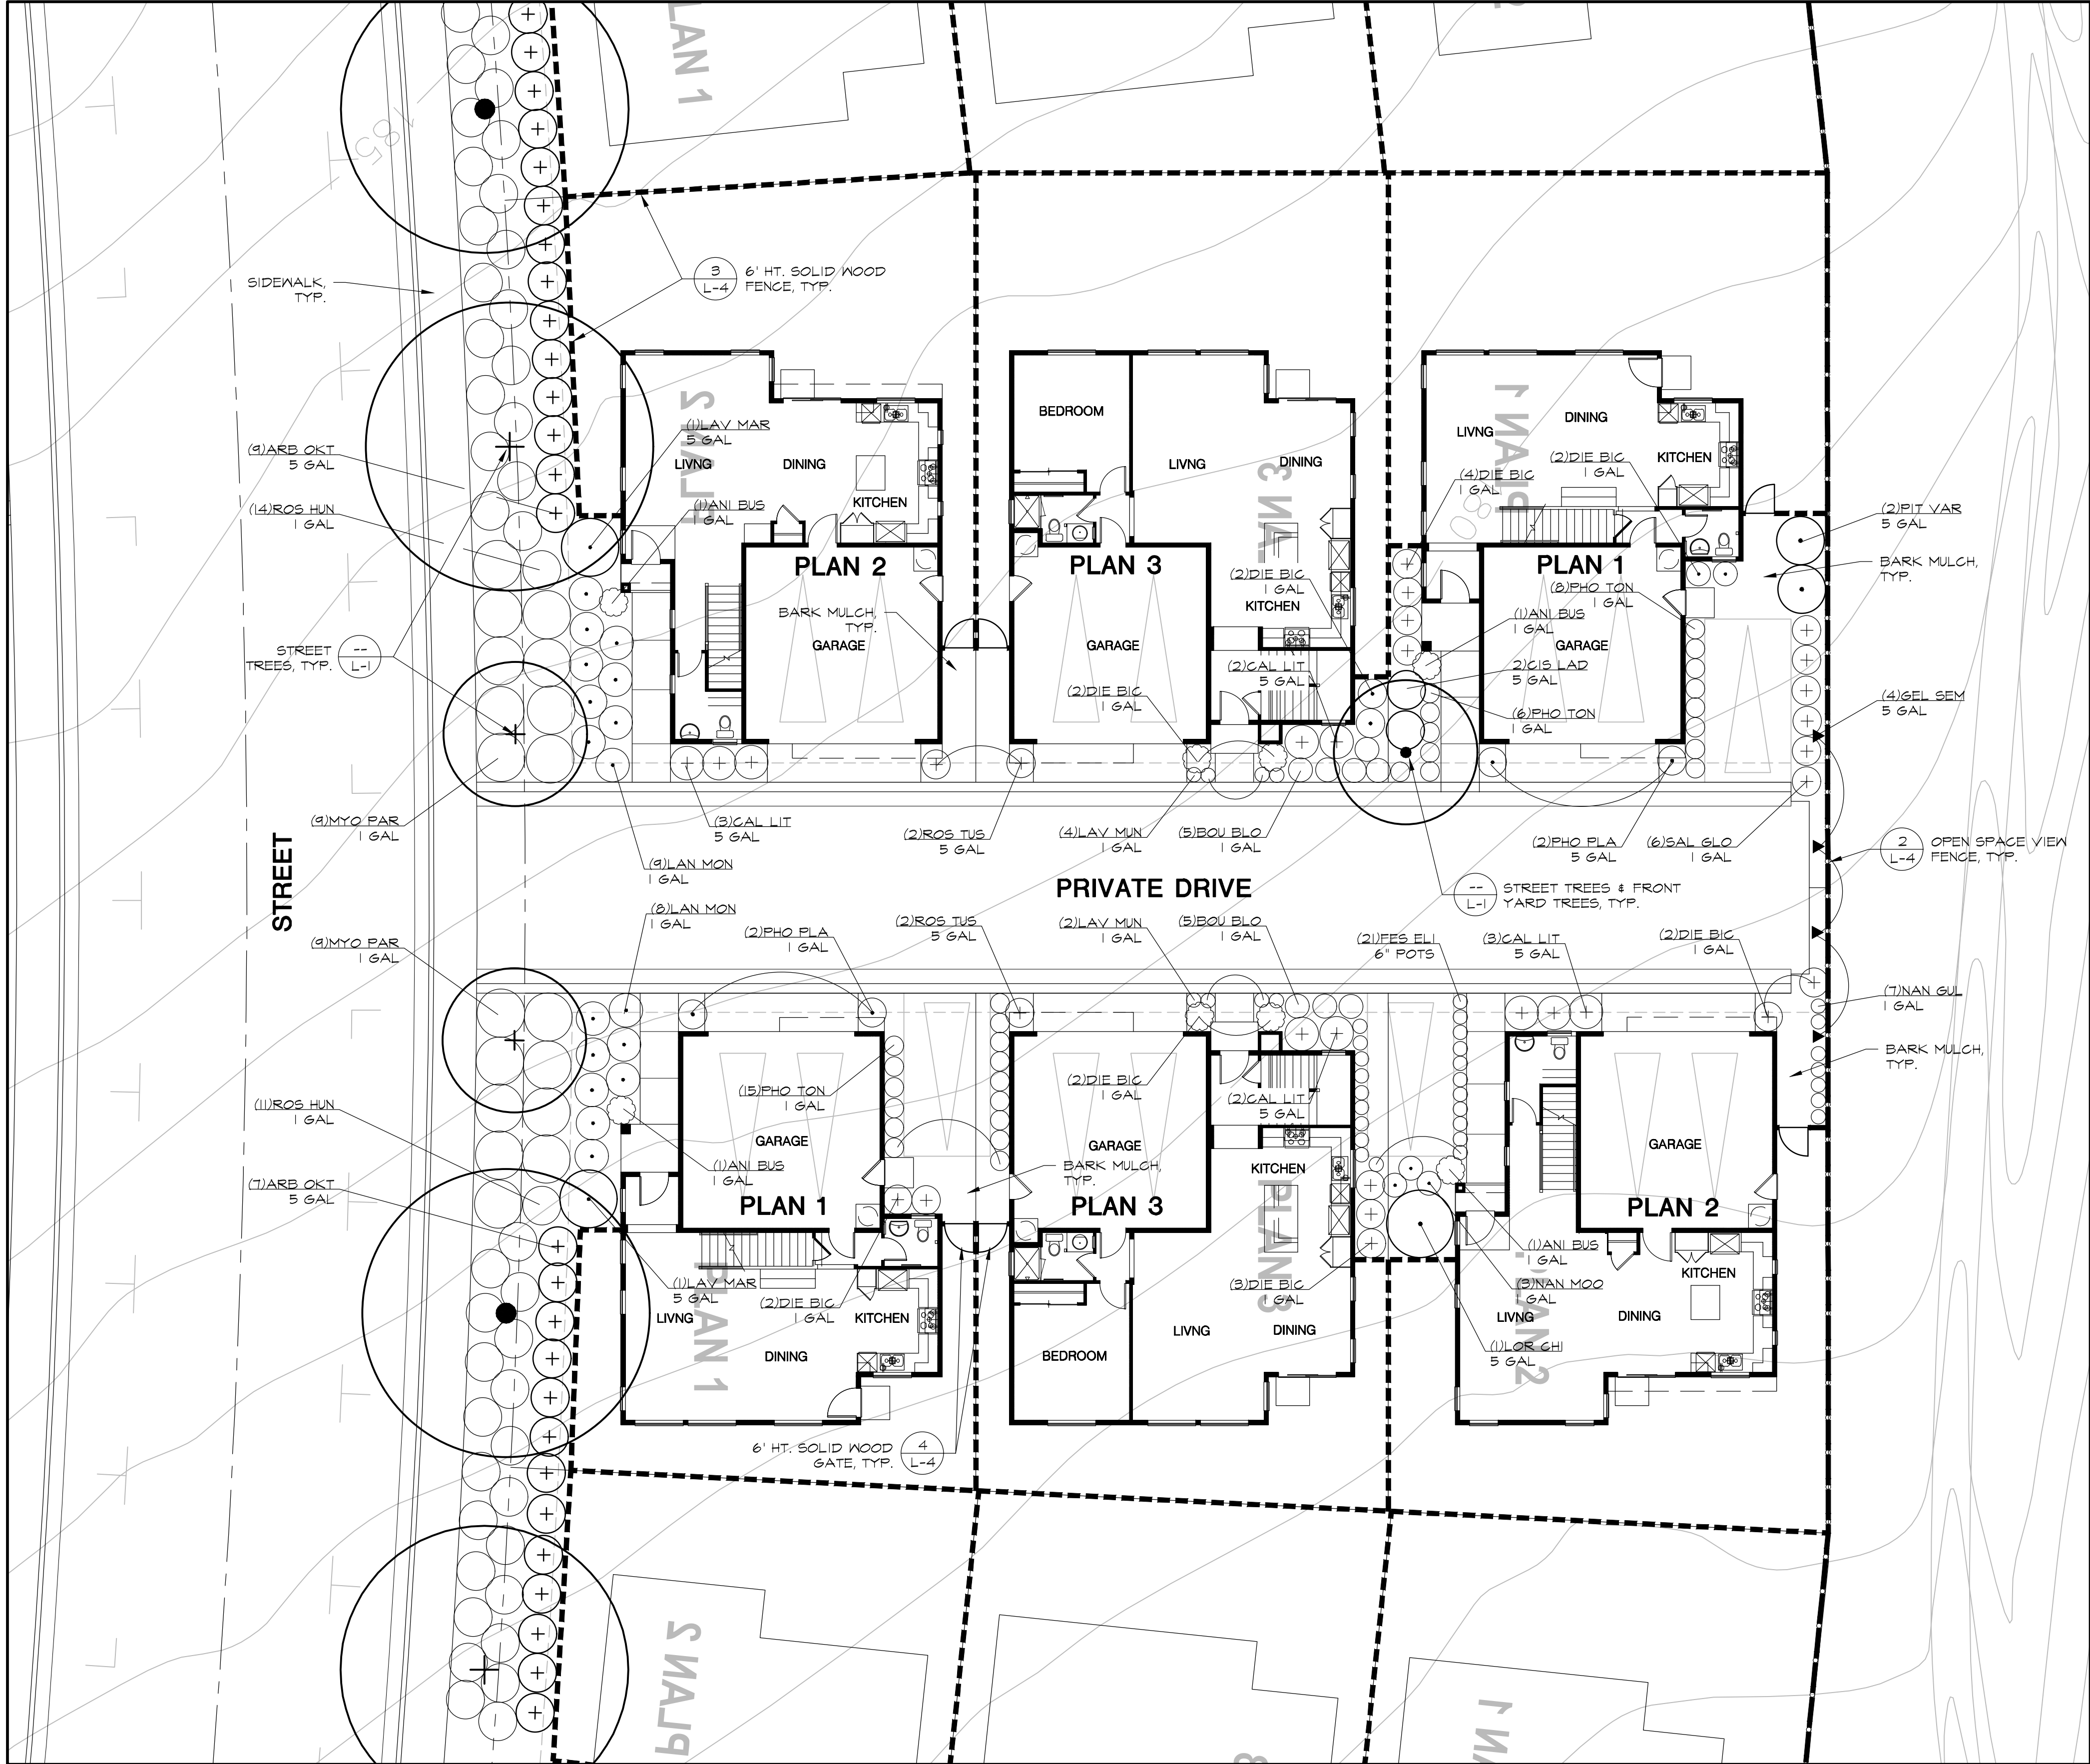

4 & 6-PACK LOT FRONT YARD TYPICALS

PRELIMINARY PLANT MATERIAL PALETTE

	BOTANICAL NAME	COMMON NAME	SIZE	SPACING	WUCOLS*
TREES - SEE STREET TREE & FENCING PLAN L-1					
SHRUBS, GROUNDCOVERS, & GRASSES PALETTE					
ANI BUS	Anigozanthos x. 'Bush Gold'	Yellow Kangaroo Paw	1 GAL	30" O.C.	L
ARB OKT	Arbutus u. 'Oktoberfest'	Strawberry Tree (Shrub)	5 GAL	60" O.C.	L
BOU BLO	Bouteloua gracilis 'Blonde Ambition'	Blonde Ambition Blue Grama	1 GAL	30" O.C.	L
CAL LIT	Callistemon v. 'Little John'	Dwarf Bottle Brush	5 GAL	42" O.C.	L
CIS LAD	Cistus ladanifer	Crimson Spot Rockrose	5 GAL	48" O.C.	L
DIE BIG	Dietes bicolor	Fortnight Lily	1 GAL	36" O.C.	L
FES ELI	Festuca glauca 'Elijah Blue'	Common Blue Fescue	6" POTS	18" O.C.	L
LAN MON	Lantana montevidensis	Trailing Lantana	1 GAL	42" O.C.	L
LAV MAR	Lavatera maritima	Tree Mallow	5 GAL	72" O.C.	L
LAV MUN	Lavandula a. 'Munstead'	Shade Alt.: Flowering Maple	1 GAL	18" O.C.	L
LOR BUR	Loropetalum chinense	Munstead Lavender	5 GAL	72" O.C.	L
MYO PAR	Myoporum parvifolium	White Fringe Flower	1 GAL	60" O.C.	L
NAN GUL	Nandina d. 'Gulf Stream'	Myoporum	1 GAL	60" O.C.	L
NAN MOO	Nandina d. 'Moon Bay'	Dwarf Heavenly Bamboo	1 GAL	18" O.C.	L
PHO PLA	Phormium x. 'Platt's Black'	Dwarf Heavenly Bamboo	1 GAL	36" O.C.	L
PHO TON	Phormium x. 'Tony Tiger'	New Zealand Flax	1 GAL	36" O.C.	L
PIT VAR	Pittosporum tobira 'Variegata'	Dwarf New Zealand Flax	1 GAL	24" O.C.	L
PRU COL	Prunus c. 'Compacta' Column	Shade Alt.: Variegated Lilly Turf	5 GAL	60" O.C.	L
ROS HUN	Rosmarinus o. 'Huntington Carpet'	Columnar Cherry Laurel	5 GAL	48" O.C.	L
ROS TUS	Rosmarinus o. 'Tuscan Blue'	Trailing Rosemary	1 GAL	48" O.C.	L
SAL GLO	Salvia g. 'Heatwave Glow'	Upright Rosemary	5 GAL	36" O.C.	L
SEM	Solanum elaeagnifolium	Heatwave Glow Sage	1 GAL	36" O.C.	L
SEMP	Solanum elaeagnifolium	Carolina Jessamine	5 GAL	SEE PLANS	L

NOTES:
1. * - THE "WUCOLS IV" RATING SYSTEM IS INDUSTRY STANDARD FOR IRRIGATION WATER NEEDS OF LANDSCAPE PLANTING IN CALIFORNIA. THE MAJORITY PLANTS SELECTED ARE RATED VERY LOW TO MEDIUM WATER REQUIREMENTS FOR THE REGION AND SHALL BE PLANTED IN SPECIFIC HYDROZONES. PLANT WATER USE RATINGS ARE: VL - VERY LOW, L - LOW, M - MEDIUM, H - HIGH.
2. SHADE ALTERNATIVE PLANT SPECIES SHALL BE USED IN AREAS PREDOMINATELY RECEIVING SHADE, SUCH AS THE NORTH SIDE OF BUILDINGS. CONTRACTOR TO FIELD VERIFY SUN/SHADE CONDITION.

IRRIGATION/MWEO DESIGN NOTE

1. A FULLY-AUTOMATIC, HYDROZONED IRRIGATION SYSTEM DESIGN COMPLIANT WITH THE CITY OF ANTIOCH'S MODEL WATER EFFICIENT LANDSCAPE ORDINANCE (MWEO) REQUIREMENTS, SHALL BE PROVIDED DURING THE BUILDING PERMIT APPROVAL PROCESS.

PLANTING NOTES

1. **SOIL AMENDMENTS:** THE CONTRACTOR SHALL ASSUME SURFACE AMENDMENTS FOR TURF, GROUNDCOVER AND SHRUB AREAS AS PER THE PRELIMINARY SOILS REPORT INCLUDED IN THESE PLANS FOR BIDDING. ACTUAL SOIL AMENDMENTS SHALL BE DETERMINED BY THE ON-SITE SOIL TEST RECOMMENDATIONS.

A. **SOIL TESTS:** PRIOR TO CONSTRUCTION THE CONTRACTOR SHALL CONDUCT HORTICULTURAL SOIL TESTS AFTER ROUGH GRADING HAS BEEN COMPLETED. TAKE AT LEAST 5 TO 10 SUB-SAMPLES OF EQUAL SIZE AT RANDOM LOCATIONS FROM THE SITE AT 6" TO 18" DEPTHS. THOROUGHLY MIX THESE SUB-SAMPLES AND SUBMIT TO A REPUTABLE SOILS LABORATORY FOR HORTICULTURAL TESTING. IN ADDITION, A GUARANTEED ANALYSIS OF A NUTRIENT RICH COMPOST AMENDMENT (SPECIFIED BELOW) MUST BE SUBMITTED WITH THE SOIL SAMPLE TO PROVIDE A COMPLETE ANALYSIS FOR THE RECOMMENDED SOIL AMENDMENT MIX.

B. A NUTRIENT RICH COMPOST AMENDMENT SHALL BE USED AS THE NITROGEN STABILIZED ORGANIC AMENDMENT. INCORPORATE 2" OF COMPOST INTO THE TOP 6" TO 12" OF SOIL. THIS PRODUCT SHALL BE CERTIFIED THROUGH THE US COMPOSTING COUNCIL'S SEAL OF TESTING ASSURANCE PROGRAM (www.compostingcouncil.org). A GUARANTEED ANALYSIS ORGANIC COMPOST SUCH AS 'WONDERGROW PREMIUM COMPOST' AVAILABLE AT GROVER LANDSCAPING (209) 545-4401 OR 'FOUR COURSE COMPOST' AVAILABLE AT JEPSON PRAIRIE ORGANICS (800) 208-2370 OR APPROVED EQUAL SHALL BE USED.

C. THE APPROVED FINAL SOIL AMENDMENT RECOMMENDATION SHALL BE EVENLY SPREAD AND THOROUGHLY BLENDED BY CROSS-RIPPING OR EQUALLY CULTIVATED BY MEANS OF ROTOTILLING TO A UNIFORM DEPTH OF 6"-12". IN AREAS WITH A SLOPE OF 3:1 OR GREATER OR WHERE PLANT MATERIAL IS SPACED 60" O.C. OR GREATER THE RECOMMENDED HORTICULTURAL BACKFILL MIX SHALL BE PER PLANT PIT ONLY-SEE PLANTING DETAILS. DO NOT AMEND SOIL WITHIN BIORETENTION AREAS. REFER TO CIVIL DRAWINGS FOR SOIL PREPARATION IN THESE AREAS. SOIL SHALL NOT BE WORKED WITH WHEN WET.

2. **MULCH:** ALL PLANTING AREAS, UNLESS OTHERWISE NOTED, SHALL RECEIVE A 3" LAYER OF MULCH AS FOLLOWS:

A. PROJECTS W/ NO SLOPES OR LESS THAN 3:1 SLOPES: RECOLOGY RECYCLED DECORATIVE MULCH IN 'LIGHT BROWN' COLOR.

B. PROJECTS W/ SLOPES STEEPER THAN 3:1: MULCH SLOPES WITH RECOLOGY 'SHREDDED CEDAR' IN 'LIGHT BROWN' COLOR.


C. MULCH AFTER ALL TREES, SHRUBS AND GROUNDCOVERS HAVE BEEN PLANTED AND AFTER PRE-EMERGENT HAS BEEN APPLIED. EXCLUDE MULCH IN TURF & HYDROSEED AREAS. NO MULCH SHALL BE PLACED WITHIN A 3" CLEAR BAND AROUND TRUNK OF ALL TREES. NO MULCH SHALL BE USED IN BIO-RETENTION BASINS-REFER TO CIVIL DWGS. FOR SOIL TYPE.

RIALTO PLACE

APN: 076-010-032, 34, 36 & 37
CITY OF ANTIOCH
CONTRA COSTA COUNTY
CALIFORNIA


GRAPHIC SYMBOL LEGEND

- DETAIL NUMBER
- SHEET NUMBER
- PLANT QUANTITY
- PLANT MATERIAL KEY (SEE SHEET L-2 & L-3)
- PLANT CONTAINER SIZE

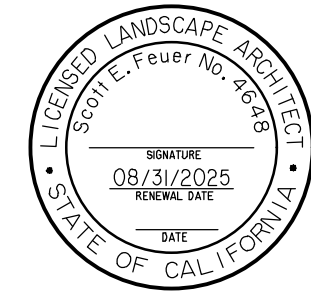


0 5 10 20 FT.


DATE: 07/23/24
JOB# 23010.01

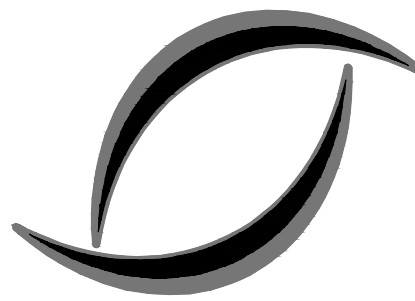


ENVIRONMENTAL
FORESIGHT, INC.
Landscape Architecture
2065 N. Broadway, Suite 203
Walnut Creek, CA 94596
T (925) 945-0300
www.environmentalforesight.com

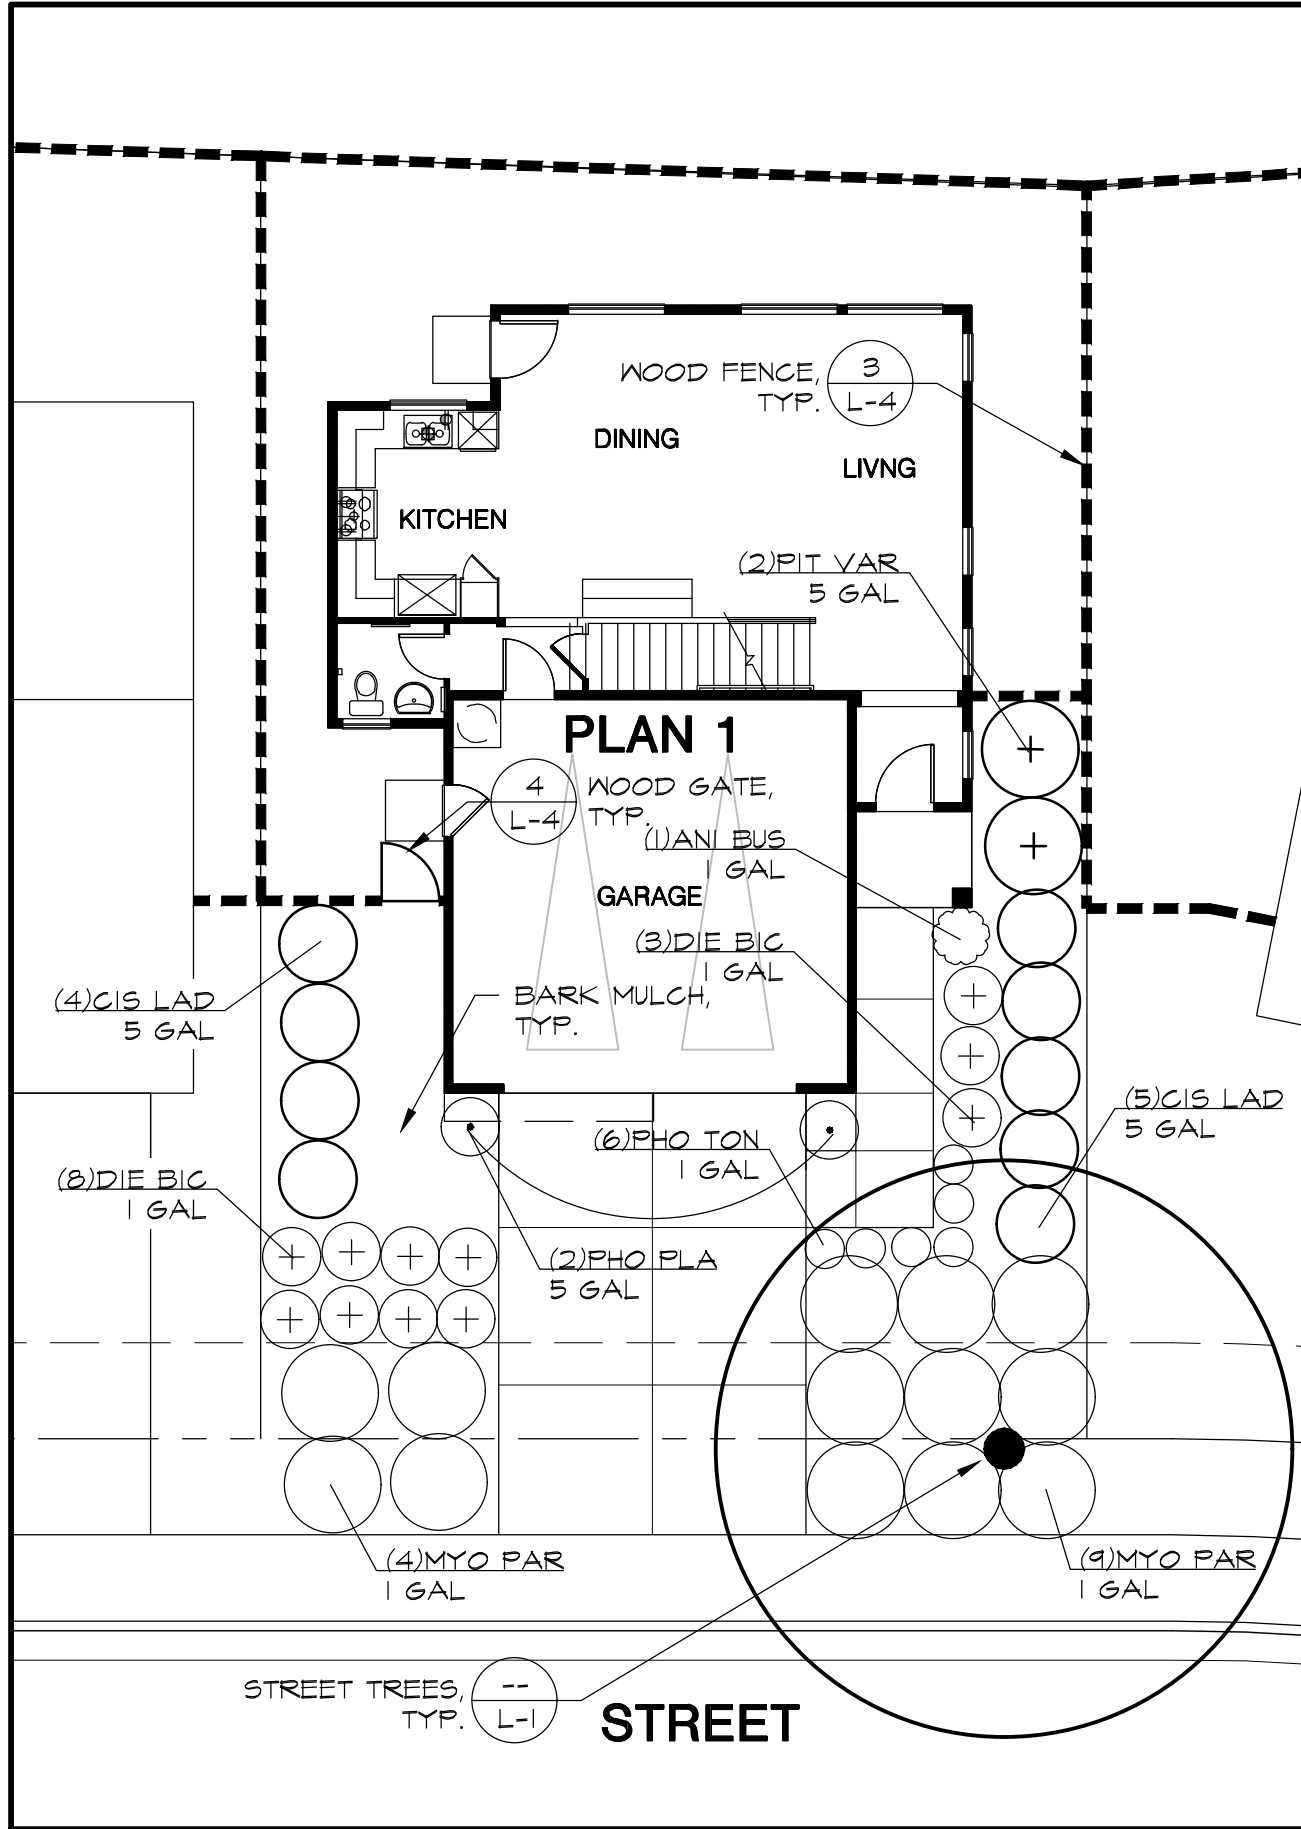


PLAN 1 FRONT YARD TYPICAL

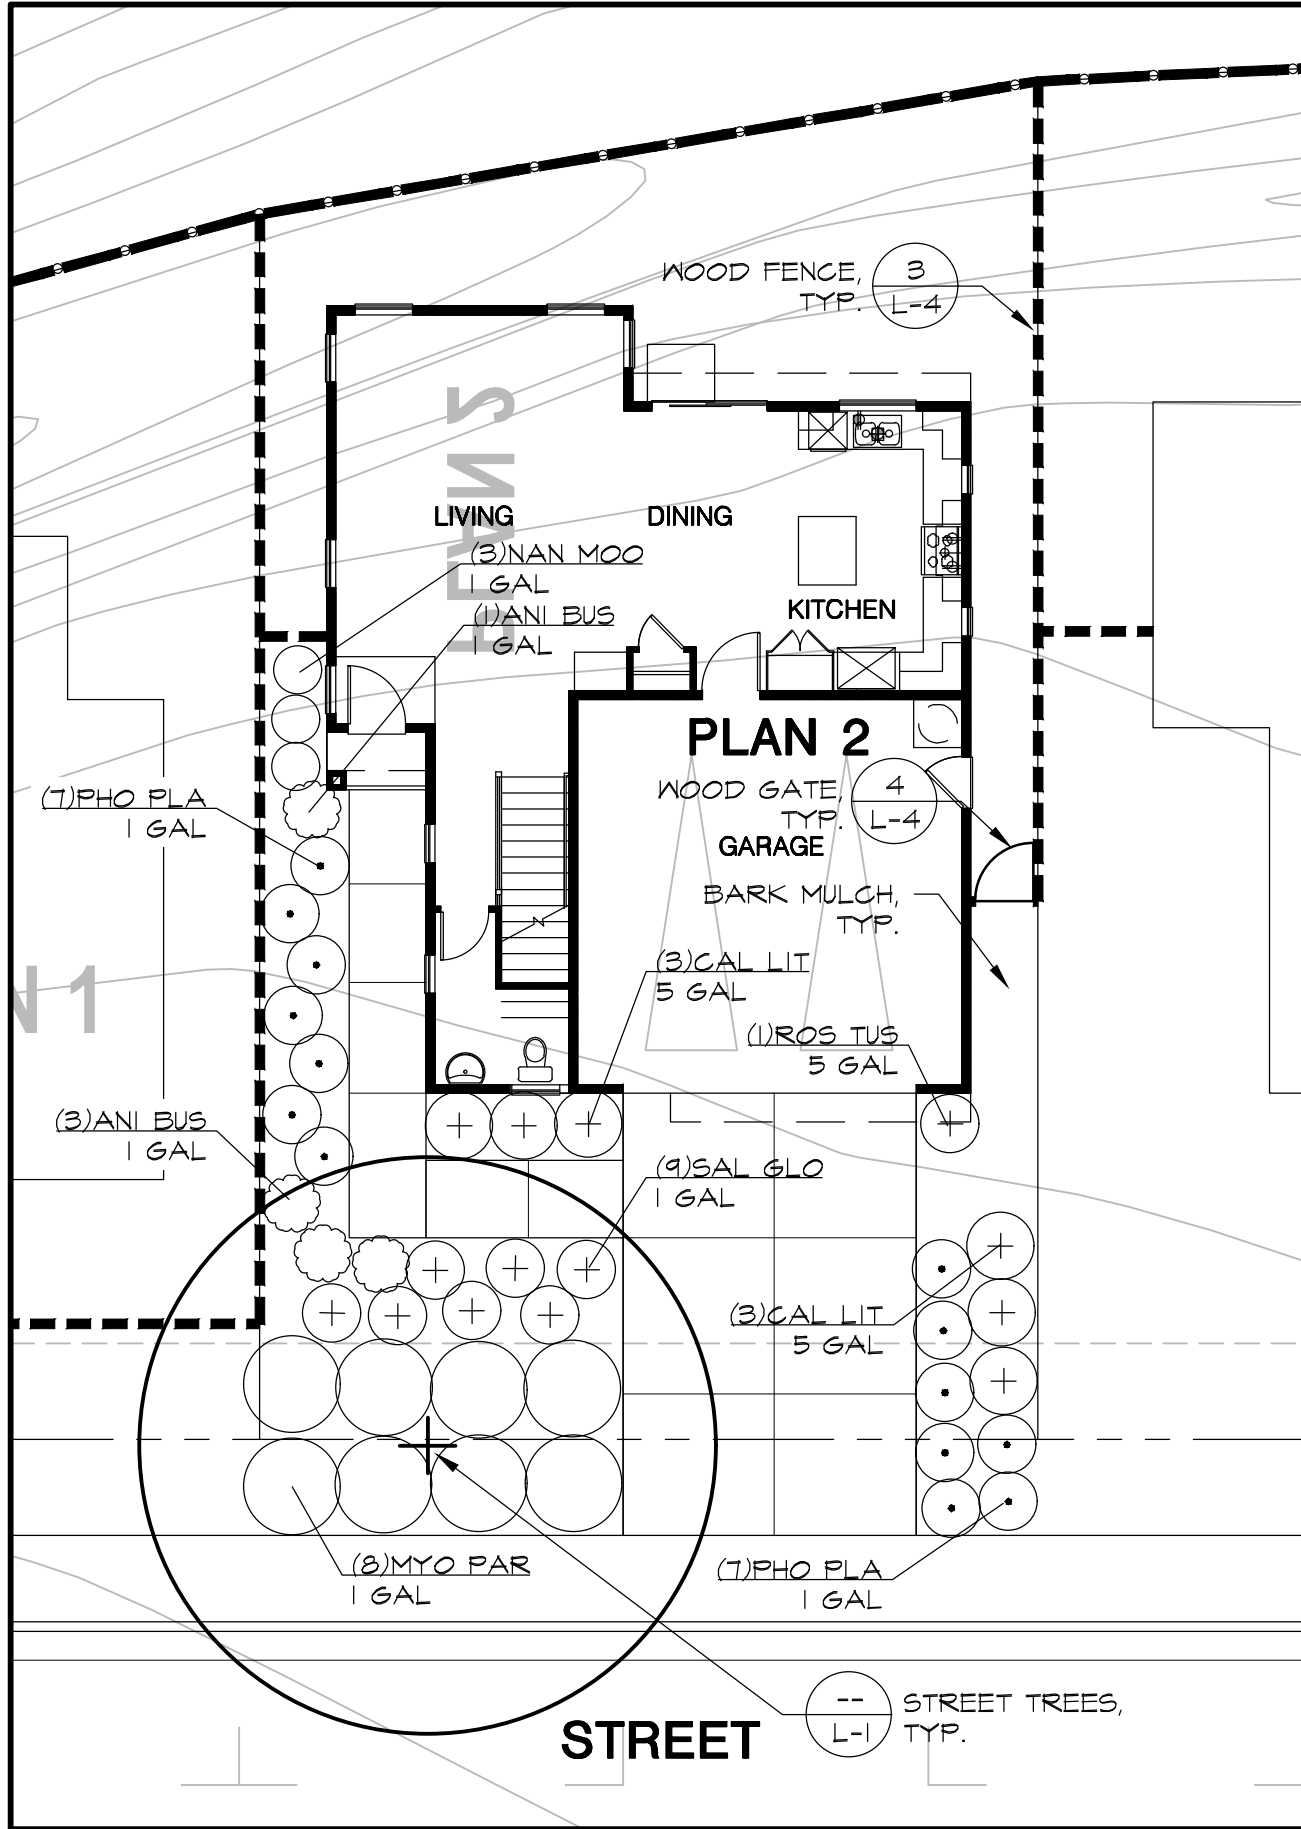


PLAN 2 FRONT YARD TYPICAL

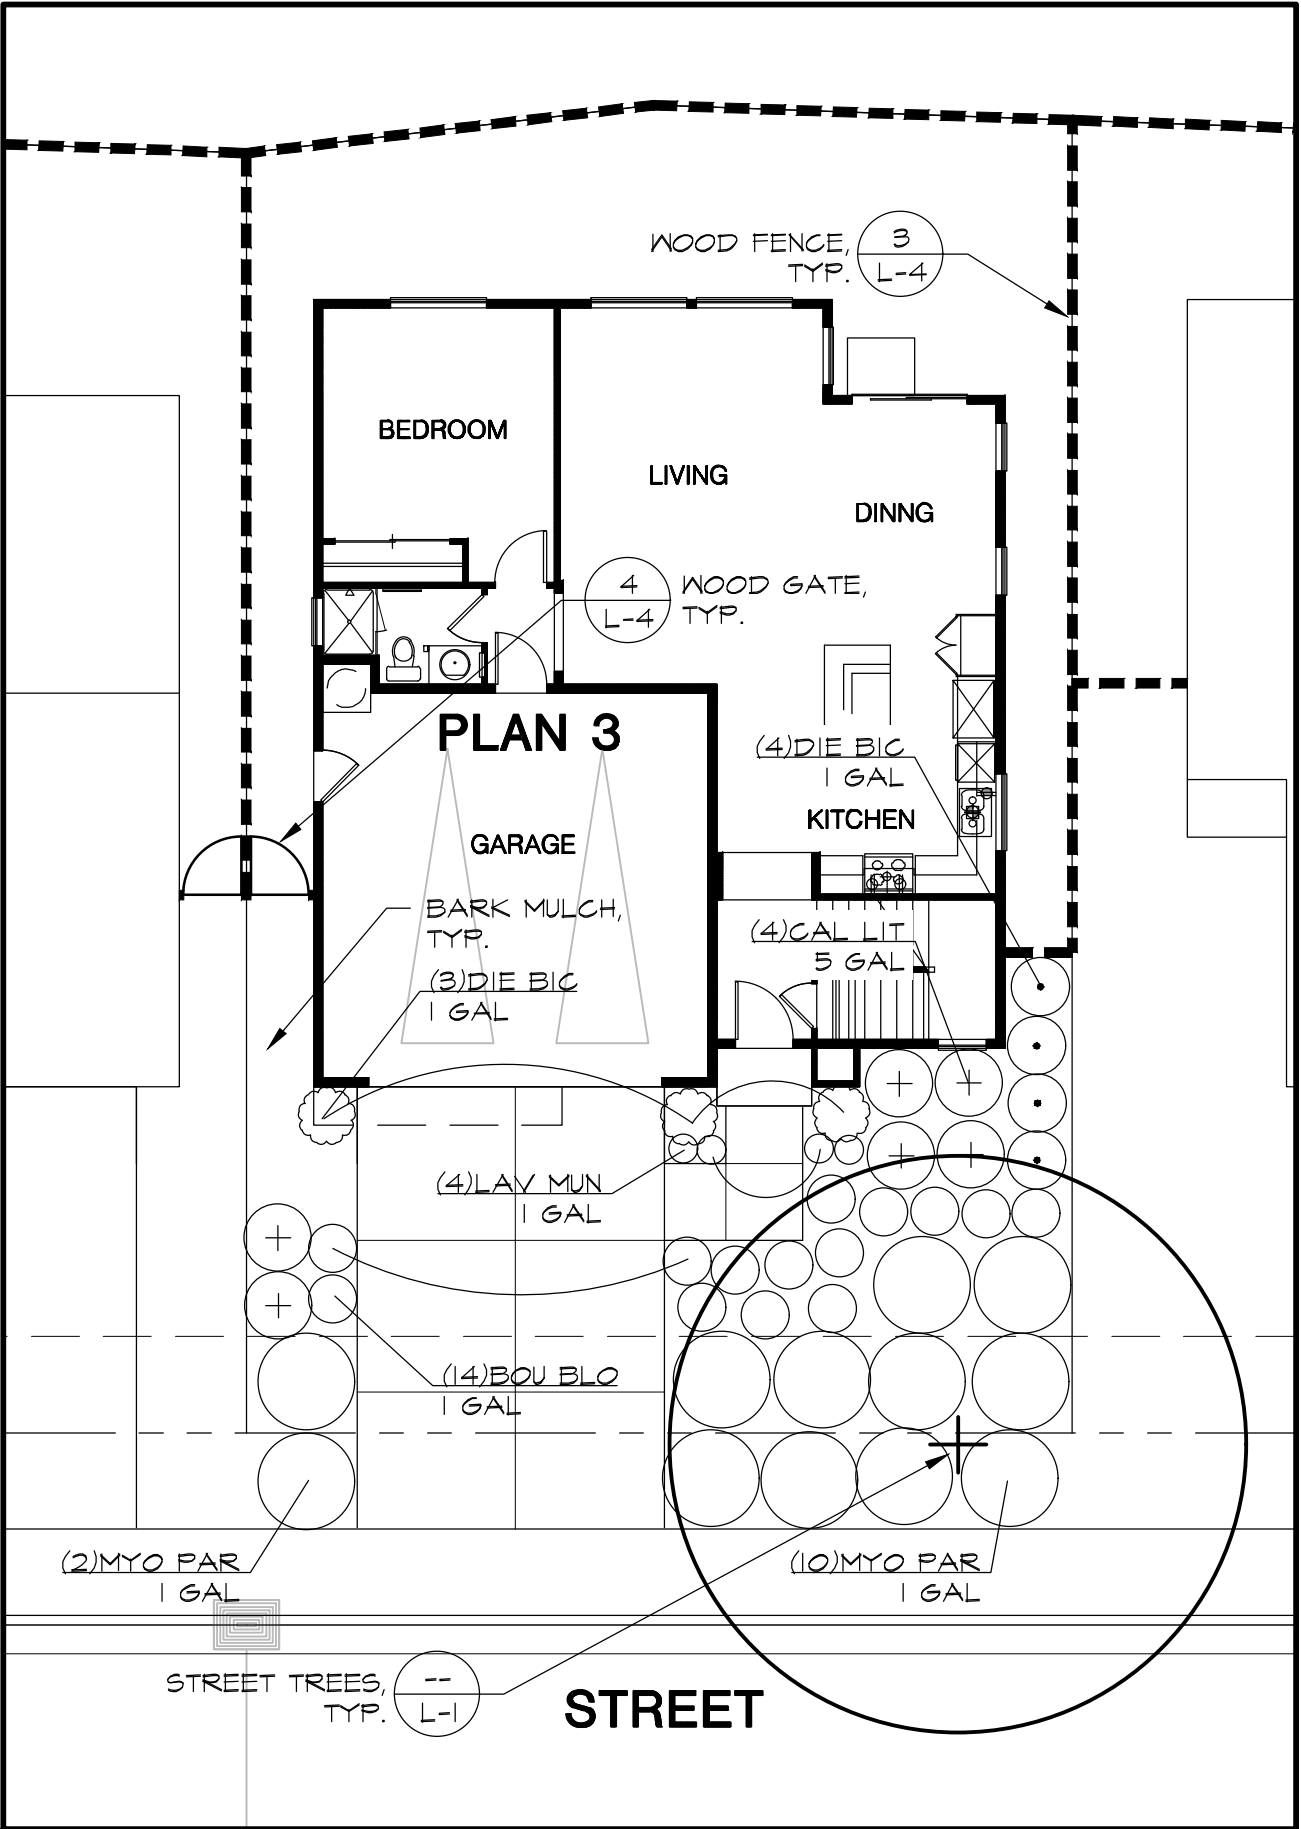

PLAN 3 FRONT YARD TYPICAL

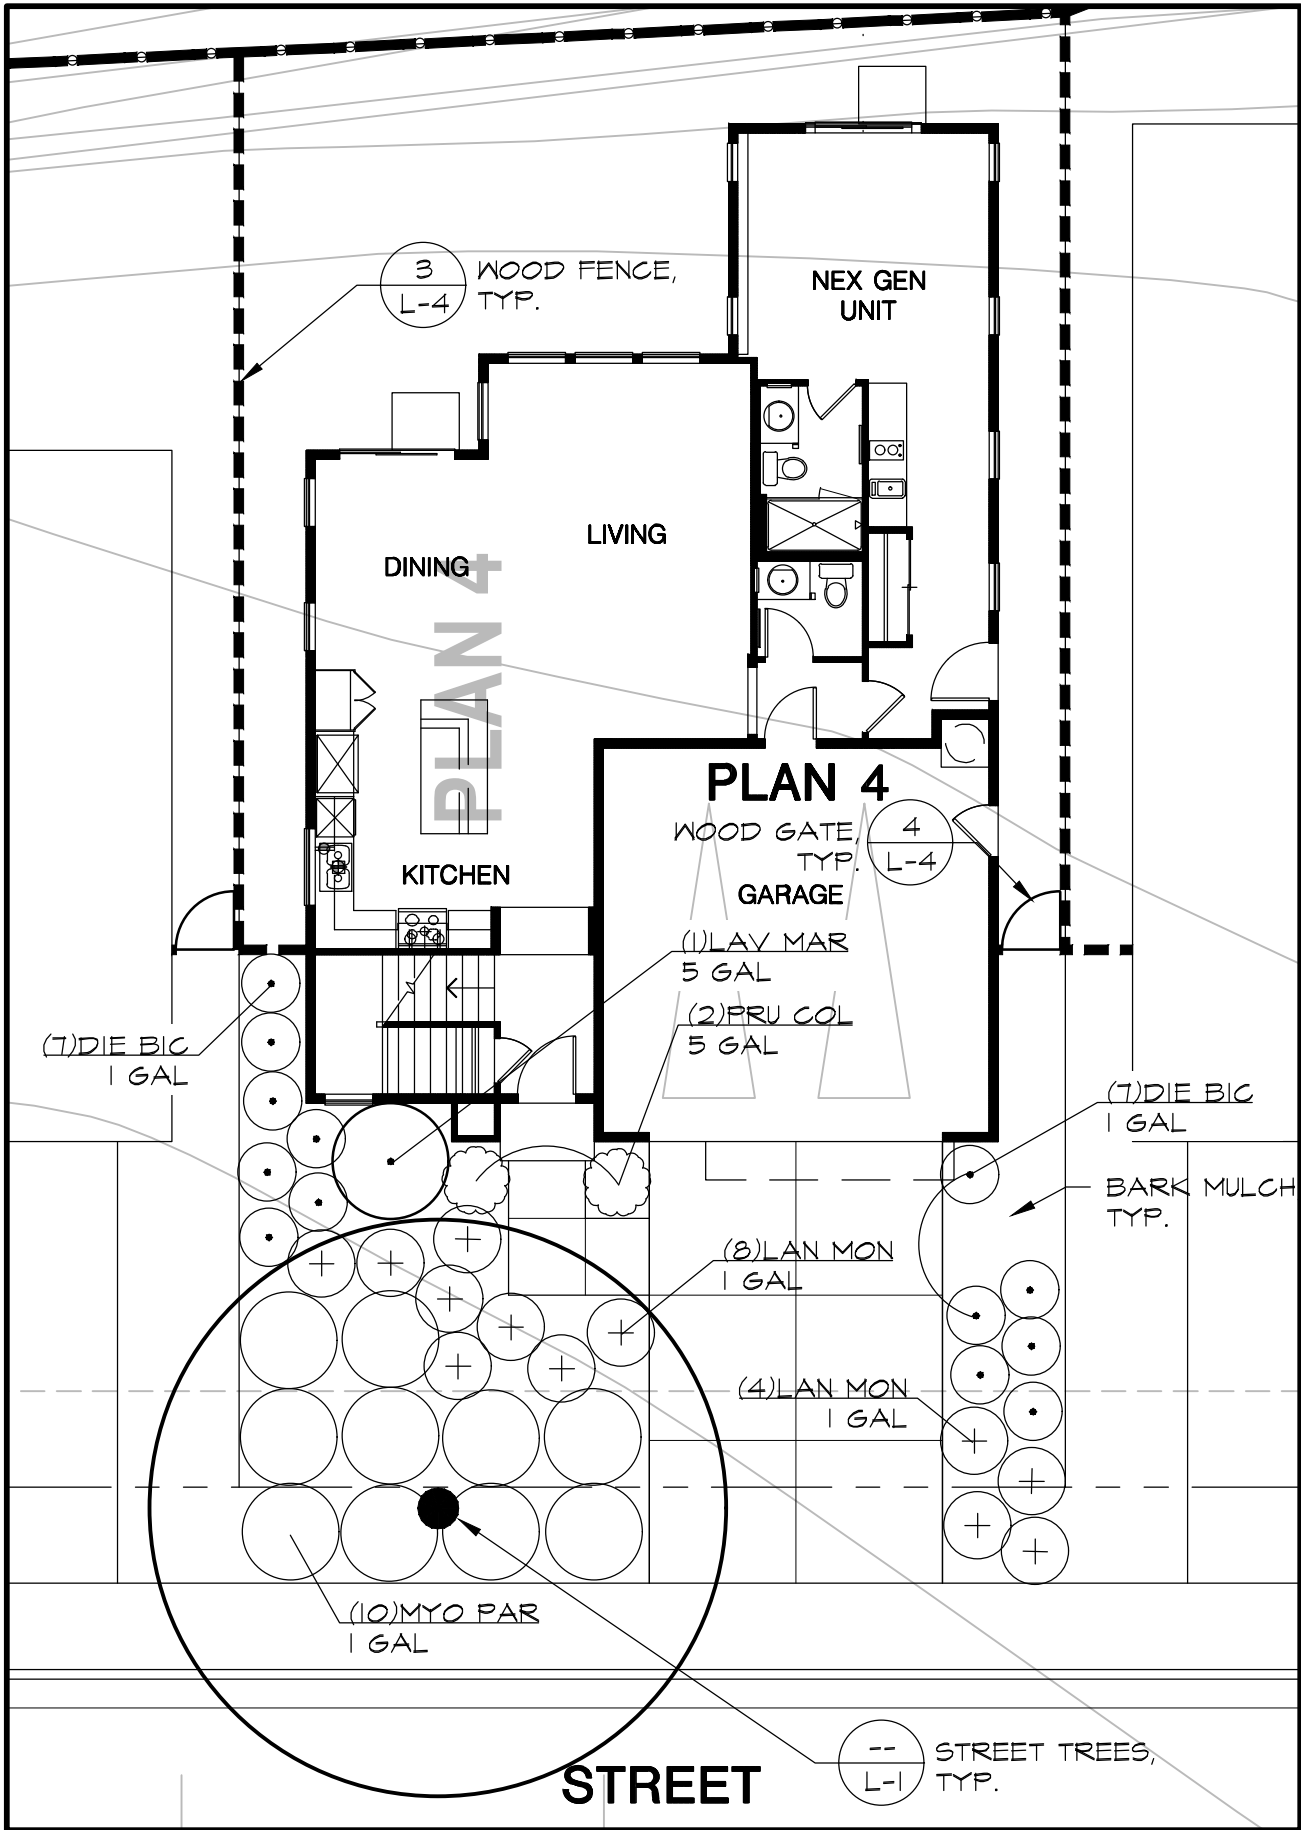

PLAN 4 FRONT YARD TYPICAL

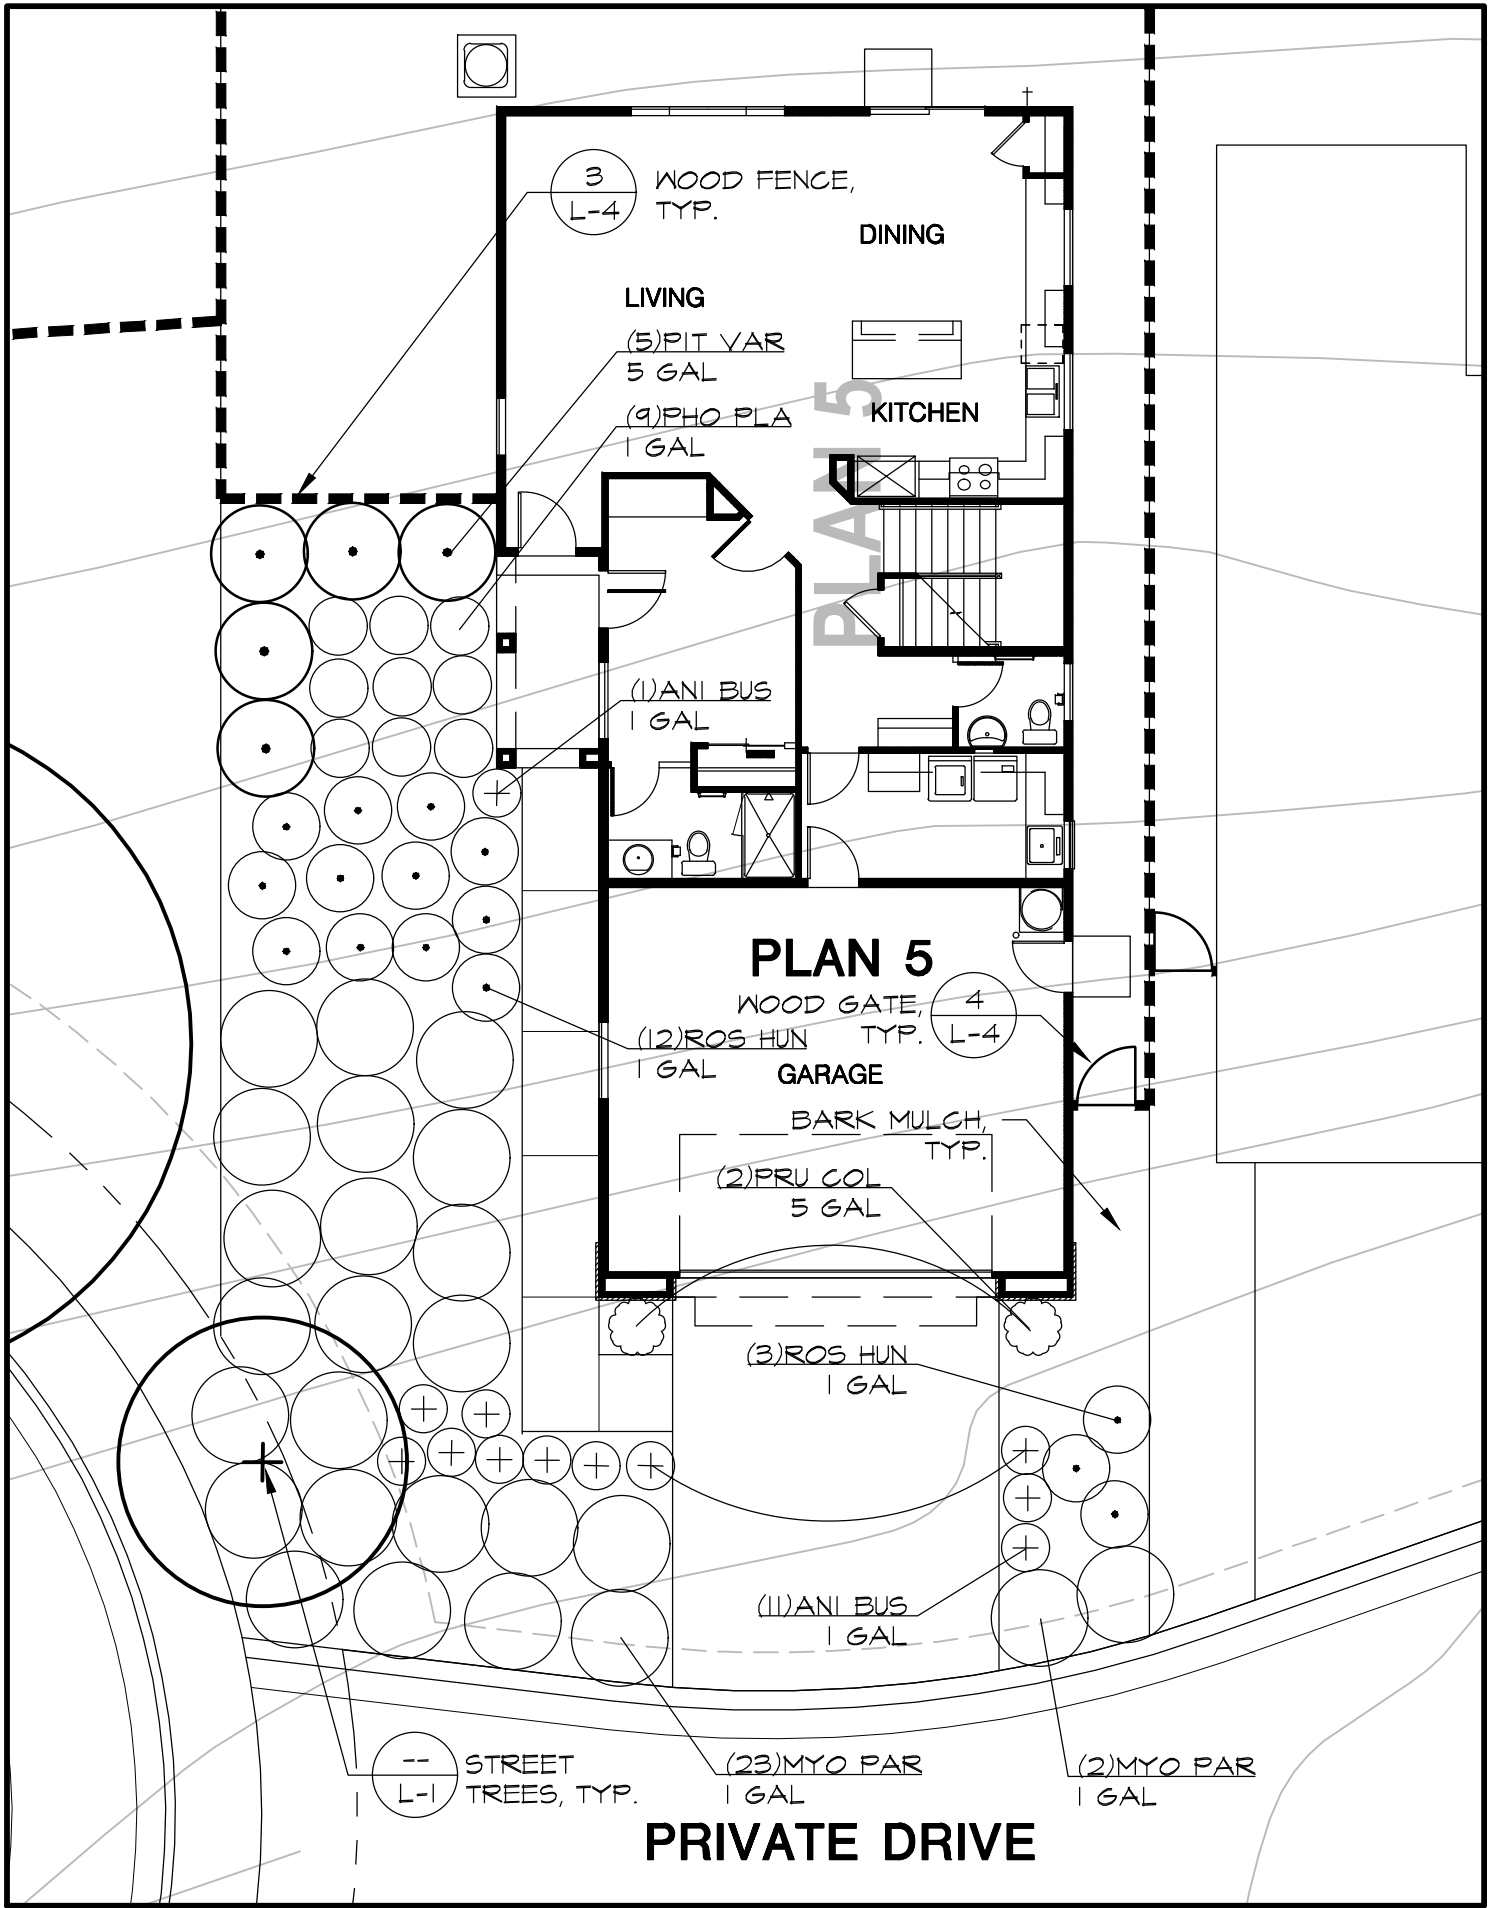

PLAN 5 FRONT YARD TYPICAL

PRELIMINARY PLANT MATERIAL PALETTE

	BOTANICAL NAME	COMMON NAME	SIZE	SPACING	WUCOLS*
TREES - SEE STREET TREE & FENCING PLAN L-1					
SHRUBS, GROUNDCOVERS, & GRASSES PALETTE					
ANI BUS	Anigozanthos x. 'Bush Gold'	Yellow Kangaroo Paw	1 GAL	30" O.C.	L
ARB OKT	Arbutus v. 'Oktoberfest'	Strawberry Tree (Shrub)	5 GAL	60" O.C.	L
BOU BLO	Bouteloua gracilis 'Blonde Ambition'	Blonde Ambition Blue Grama	1 GAL	30" O.C.	L
CAL LIT	Callistemon v. 'Little John'	Dwarf Bottle Brush	5 GAL	42" O.C.	L
CIS LAD	Cistus ladanifer	Crimson Spot Rockrose	5 GAL	48" O.C.	L
DIE BIG	Dietses bicolor	Fortnight Lily	1 GAL	36" O.C.	L
FES ELI	Festuca glauca 'Elijah Blue'	Common Blue Fescue	6" POTS	18" O.C.	L
LAN MON	Lantana montevidensis	Trailing Lantana	1 GAL	42" O.C.	L
LAV MAR	Lavatera maritima	Tree Mallow	5 GAL	72" O.C.	L
LAV MUN	Lavandula a. 'Munstead'	Shade Alt.: Flowering Maple	1 GAL	18" O.C.	L
LOR BUR	Loropetalum chinense	Munstead Lavender	5 GAL	72" O.C.	L
MYO PAR	Myoporum parvifolium	White Fringe Flower	1 GAL	60" O.C.	L
NAN GUL	Nandina d. 'Gulf Stream'	Myoporum	1 GAL	18" O.C.	L
NAN MOO	Nandina d. 'Moon Bay'	Dwarf Heavenly Bamboo	1 GAL	30" O.C.	L
PHO PLA	Phormium x. 'Platt's Black'	Dwarf Heavenly Bamboo	1 GAL	36" O.C.	L
PHO TON	Phormium x. 'Tony Tiger'	New Zealand Flax	1 GAL	24" O.C.	L
PIT VAR	Pittasporum tobira 'Variegata'	Dwarf New Zealand Flax	5 GAL	60" O.C.	L
PRU COL	Prunus c. 'Compacta' Column	Shade Alt.: Variegated Lily Turf	5 GAL	48" O.C.	L
ROS HUN	Rosmarinus o. 'Huntington Carpet'	Columnar Cherry Laurel	1 GAL	48" O.C.	L
ROS TUS	Rosmarinus o. 'Tuscan Blue'	Trailing Rosemary	5 GAL	48" O.C.	L
SAL GLO	Salvia g. 'Heatwave Glow'	Upright Rosemary	5 GAL	36" O.C.	L
VINES / ESPALIERS					
SEL SEM	Gelsemium sempervirens	Heatwave Glow Sage	5 GAL	36" O.C.	L
		Carolina Jessamine	5 GAL	SEE PLANS	L

NOTES:
1. * - THE "WUCOLS IV" RATING SYSTEM IS INDUSTRY STANDARD FOR IRRIGATION WATER NEEDS OF LANDSCAPE PLANTING IN CALIFORNIA. THE MAJORITY PLANTS SELECTED ARE RATED VERY LOW TO MEDIUM WATER REQUIREMENTS FOR THE REGION AND SHALL BE PLANTED IN SPECIFIC HYDROZONES. PLANT WATER USE RATINGS ARE: VL - VERY LOW, L - LOW, M - MEDIUM, H - HIGH.
2. SHADE ALTERNATIVE PLANT SPECIES SHALL BE USED IN AREAS PREDOMINATELY RECEIVING SHADE, SUCH AS THE NORTH SIDE OF BUILDINGS. CONTRACTOR TO FIELD VERIFY SUN/SHADE CONDITION.

IRRIGATION/MWEO DESIGN NOTE


1. A FULLY-AUTOMATIC, HYDROZONED IRRIGATION SYSTEM DESIGN COMPLIANT WITH THE CITY OF ANTIOCH'S MODEL WATER EFFICIENT LANDSCAPE ORDINANCE (MWEO) REQUIREMENTS, SHALL BE PROVIDED DURING THE BUILDING PERMIT APPROVAL PROCESS.

PLANTING NOTES

1. **SOIL AMENDMENTS:** THE CONTRACTOR SHALL ASSUME SURFACE AMENDMENTS FOR TURF, GROUNDCOVER AND SHRUB AREAS AS PER THE PRELIMINARY SOILS REPORT INCLUDED IN THESE PLANS FOR BIDDING. ACTUAL SOIL AMENDMENTS SHALL BE DETERMINED BY THE ON-SITE SOIL TEST RECOMMENDATIONS.
- A. **SOIL TESTS:** PRIOR TO CONSTRUCTION THE CONTRACTOR SHALL CONDUCT HORTICULTURAL SOIL TESTS AFTER ROUGH GRADING HAS BEEN COMPLETED. TAKE AT LEAST 5 TO 10 SUB-SAMPLES OF EQUAL SIZE AT RANDOM LOCATIONS FROM THE SITE AT 6" TO 18" DEPTHS. THOROUGHLY MIX THESE SUB-SAMPLES AND SUBMIT TO A REPUTABLE SOILS LABORATORY FOR HORTICULTURAL TESTING. IN ADDITION, A GUARANTEED ANALYSIS OF A NUTRIENT RICH COMPOST AMENDMENT (SPECIFIED BELOW) MUST BE SUBMITTED WITH THE SOIL SAMPLE TO PROVIDE A COMPLETE ANALYSIS FOR THE RECOMMENDED SOIL AMENDMENT MIX.
- B. A NUTRIENT RICH COMPOST AMENDMENT SHALL BE USED AS THE NITROGEN STABILIZED ORGANIC AMENDMENT. INCORPORATE 2" OF COMPOST INTO THE TOP 6" TO 12" OF SOIL. THIS PRODUCT SHALL BE CERTIFIED THROUGH THE US COMPOSTING COUNCIL'S SEAL OF TESTING ASSURANCE PROGRAM (www.compostingcouncil.org). A GUARANTEED ANALYSIS ORGANIC COMPOST SUCH AS 'WONDERSGROW PREMIUM COMPOST' AVAILABLE AT GROVER LANDSCAPING (209) 545-4401 OR 'FOUR COURSE COMPOST' AVAILABLE AT JEPSON PRAIRIE ORGANICS (800) 208-2370 OR APPROVED EQUAL SHALL BE USED.
- C. THE APPROVED FINAL SOIL AMENDMENT RECOMMENDATION SHALL BE EVENLY SPREAD AND THOROUGHLY BLENDED BY CROSS-RIPPING OR EQUALLY CULTIVATED BY MEANS OF ROTOTILLING TO A UNIFORM DEPTH OF 6"-12". IN AREAS WITH A SLOPE OF 3:1 OR GREATER OR WHERE PLANT MATERIAL IS SPACED 60" O.C. OR GREATER THE RECOMMENDED HORTICULTURAL BACKFILL MIX SHALL BE PER PLANT PIT ONLY-SEE PLANTING DETAILS. DO NOT AMEND SOIL WITHIN BIORETENTION AREAS. REFER TO CIVIL DRAWINGS FOR SOIL PREPARATION IN THESE AREAS. SOIL SHALL NOT BE WORKED WITH WHEN WET.
2. **MULCH:** ALL PLANTING AREAS, UNLESS OTHERWISE NOTED, SHALL RECEIVE A 3" LAYER OF MULCH AS FOLLOWS:
- A. PROJECTS W/ NO SLOPES OR LESS THAN 3:1 SLOPES: RECYCLED RECYCLED DECORATIVE MULCH IN 'LIGHT BROWN' COLOR.
- B. PROJECTS W/ SLOPES STEEPER THAN 3:1: MULCH SLOPES WITH RECYCLED 'SHREDDED CEDAR' IN 'LIGHT BROWN' COLOR.
- C. MULCH AFTER ALL TREES, SHRUBS AND GROUNDCOVERS HAVE BEEN PLANTED AND AFTER PRE EMERGENT HAS BEEN APPLIED. EXCLUDE MULCH IN TURF & HYDROSEED AREAS. NO MULCH SHALL BE PLACED WITHIN A 3" CLEAR BAND AROUND TRUNK OF ALL TREES. NO MULCH SHALL BE USED IN BIO-RETENTION BASINS-REFER TO CIVIL DWGS. FOR SOIL TYPE.

RIALTO PLACE


APN: 076-010-032, 34, 36 & 37
CITY OF ANTIOCH
CONTRA COSTA COUNTY
CALIFORNIA

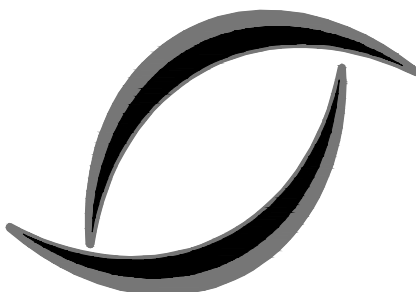

ENVIRONMENTAL
FORESIGHT, INC.
Landscape Architecture
2065 N. Broadway, Suite 203
Walnut Creek, CA 94596
T (925) 945-0300
www.environmentalforesight.com

GRAPHIC SYMBOL LEGEND


- 1 - DETAIL NUMBER
L-3 - SHEET NUMBER
PLANT QUANTITY
PLANT MATERIAL KEY (SEE SHEET L-2 & L-3)
PLANT CONTAINER SIZE

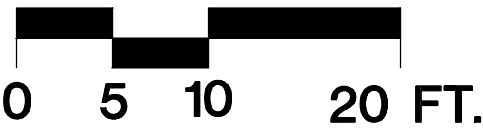


DATE: 07/23/24
JOB# 23010.01

TENTATIVE MAP: LANDSCAPE TYPICALS
SINGLE LOADED LOTS PLANS 1-5


NOT FOR CONSTRUCTION

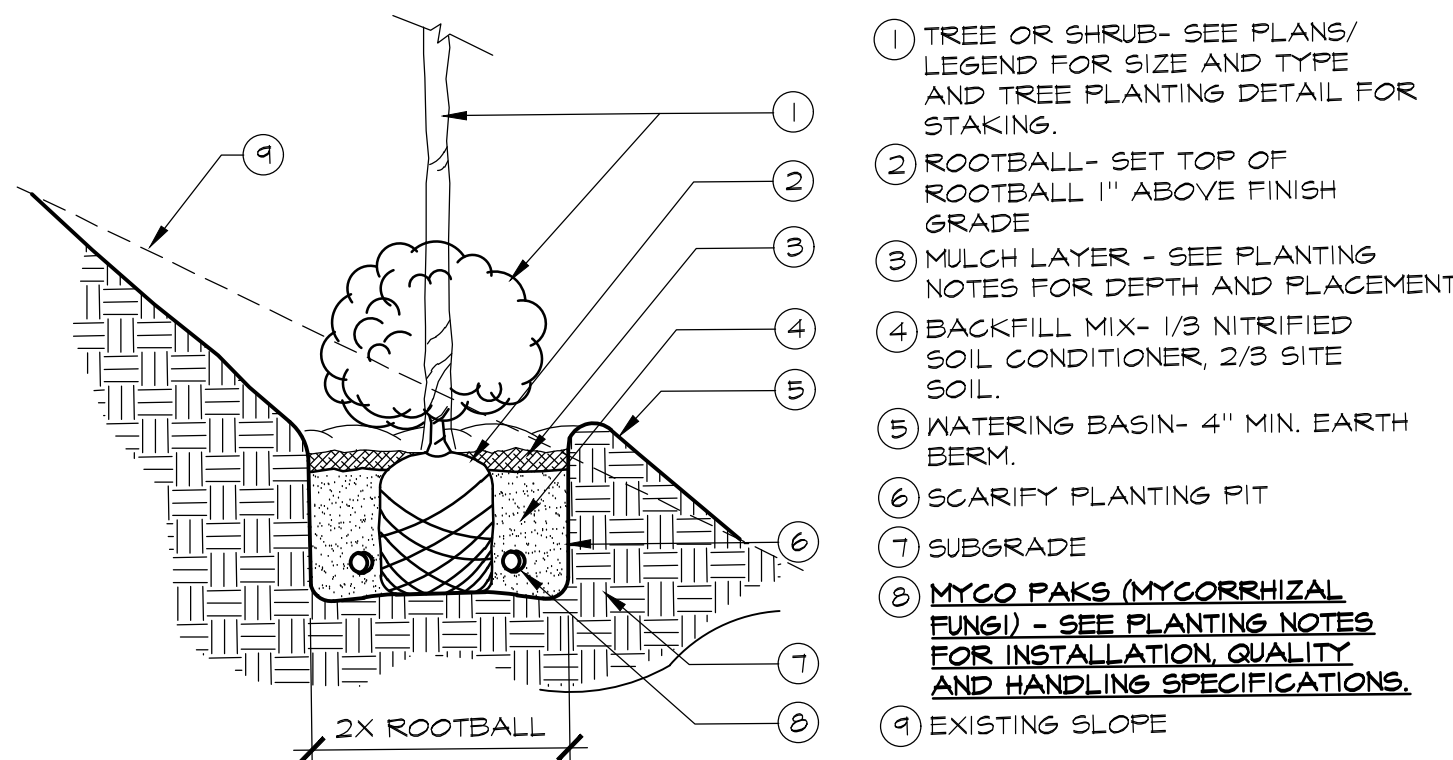


6 PLANTING ON SLOPE SCALE: N.T.S.
1/1 DT-Shrub-Agriform02.dwg

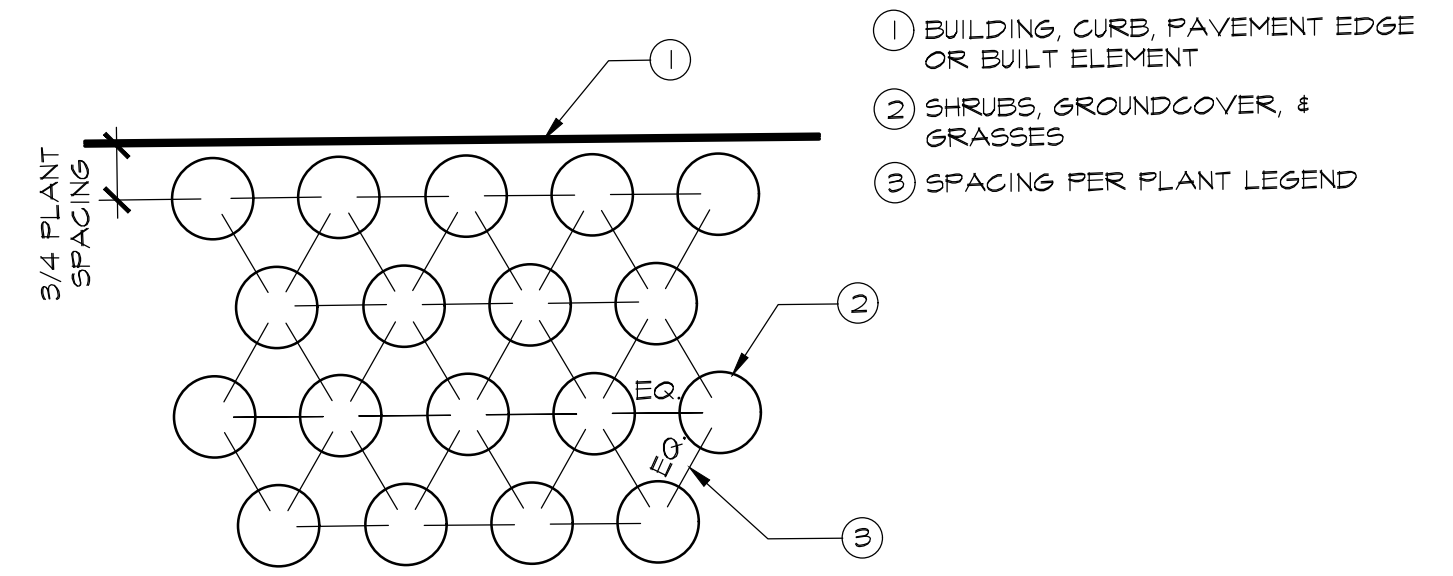

7 PLANT SPACING/LAYOUT SCALE: N.T.S.
1/1 DT-GraCov01.dwg

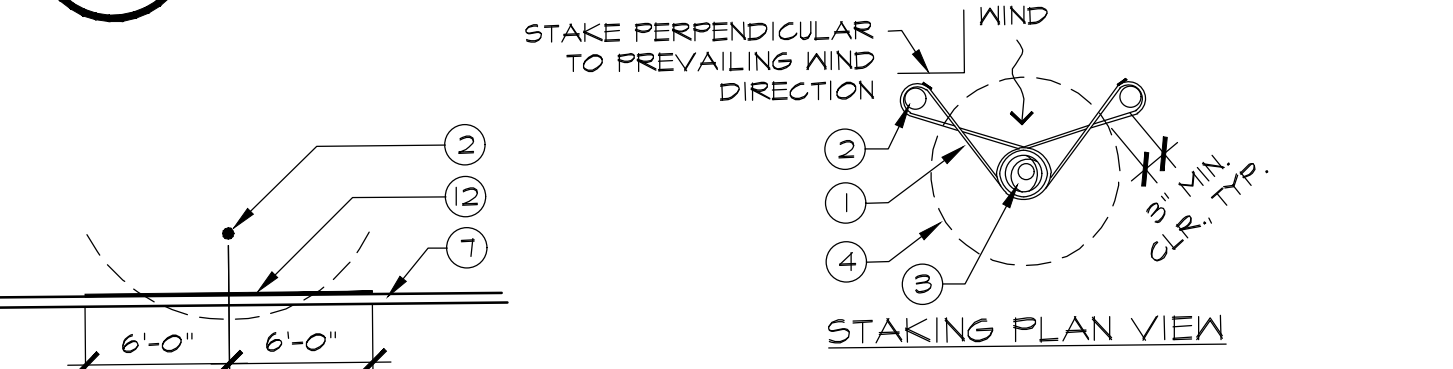


ROOT BARRIER PLAN VIEW


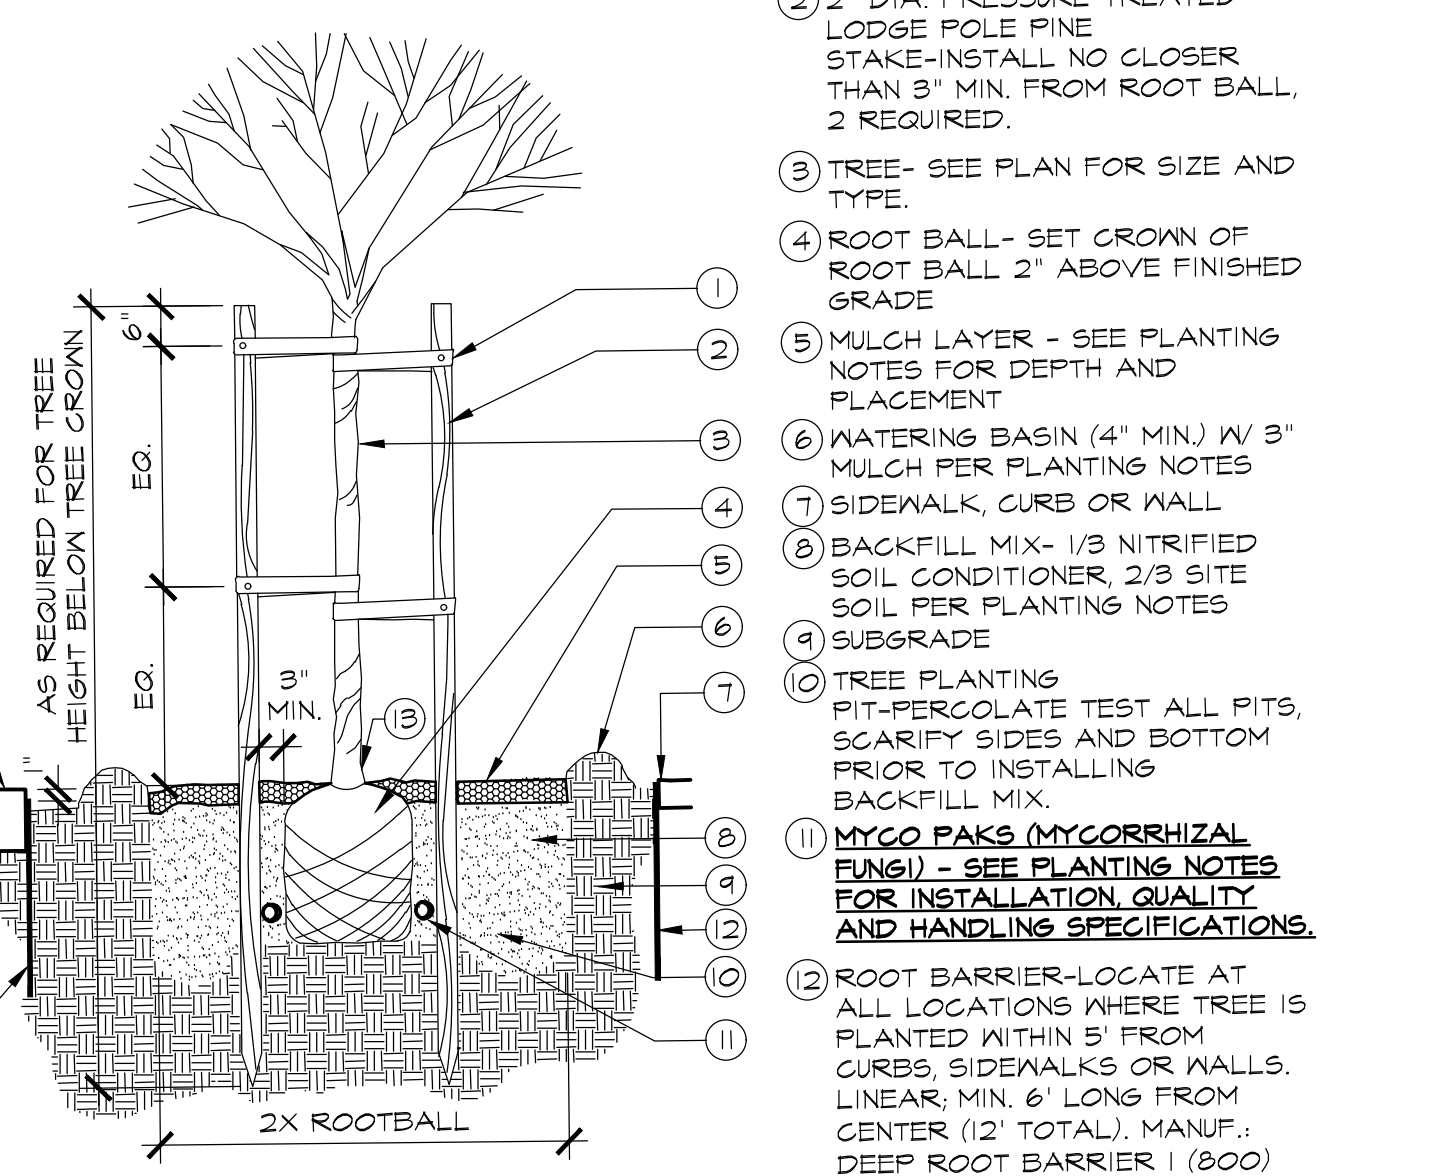


NOTES:
1. SEE PLANTING NOTES AND/OR SPECIFICATIONS FOR ADDITIONAL INFORMATION.

8 TREE PLANTING WITH ROOT BARRIER SCALE: N.T.S.
1/1 DT-Tree-Green01.dwg

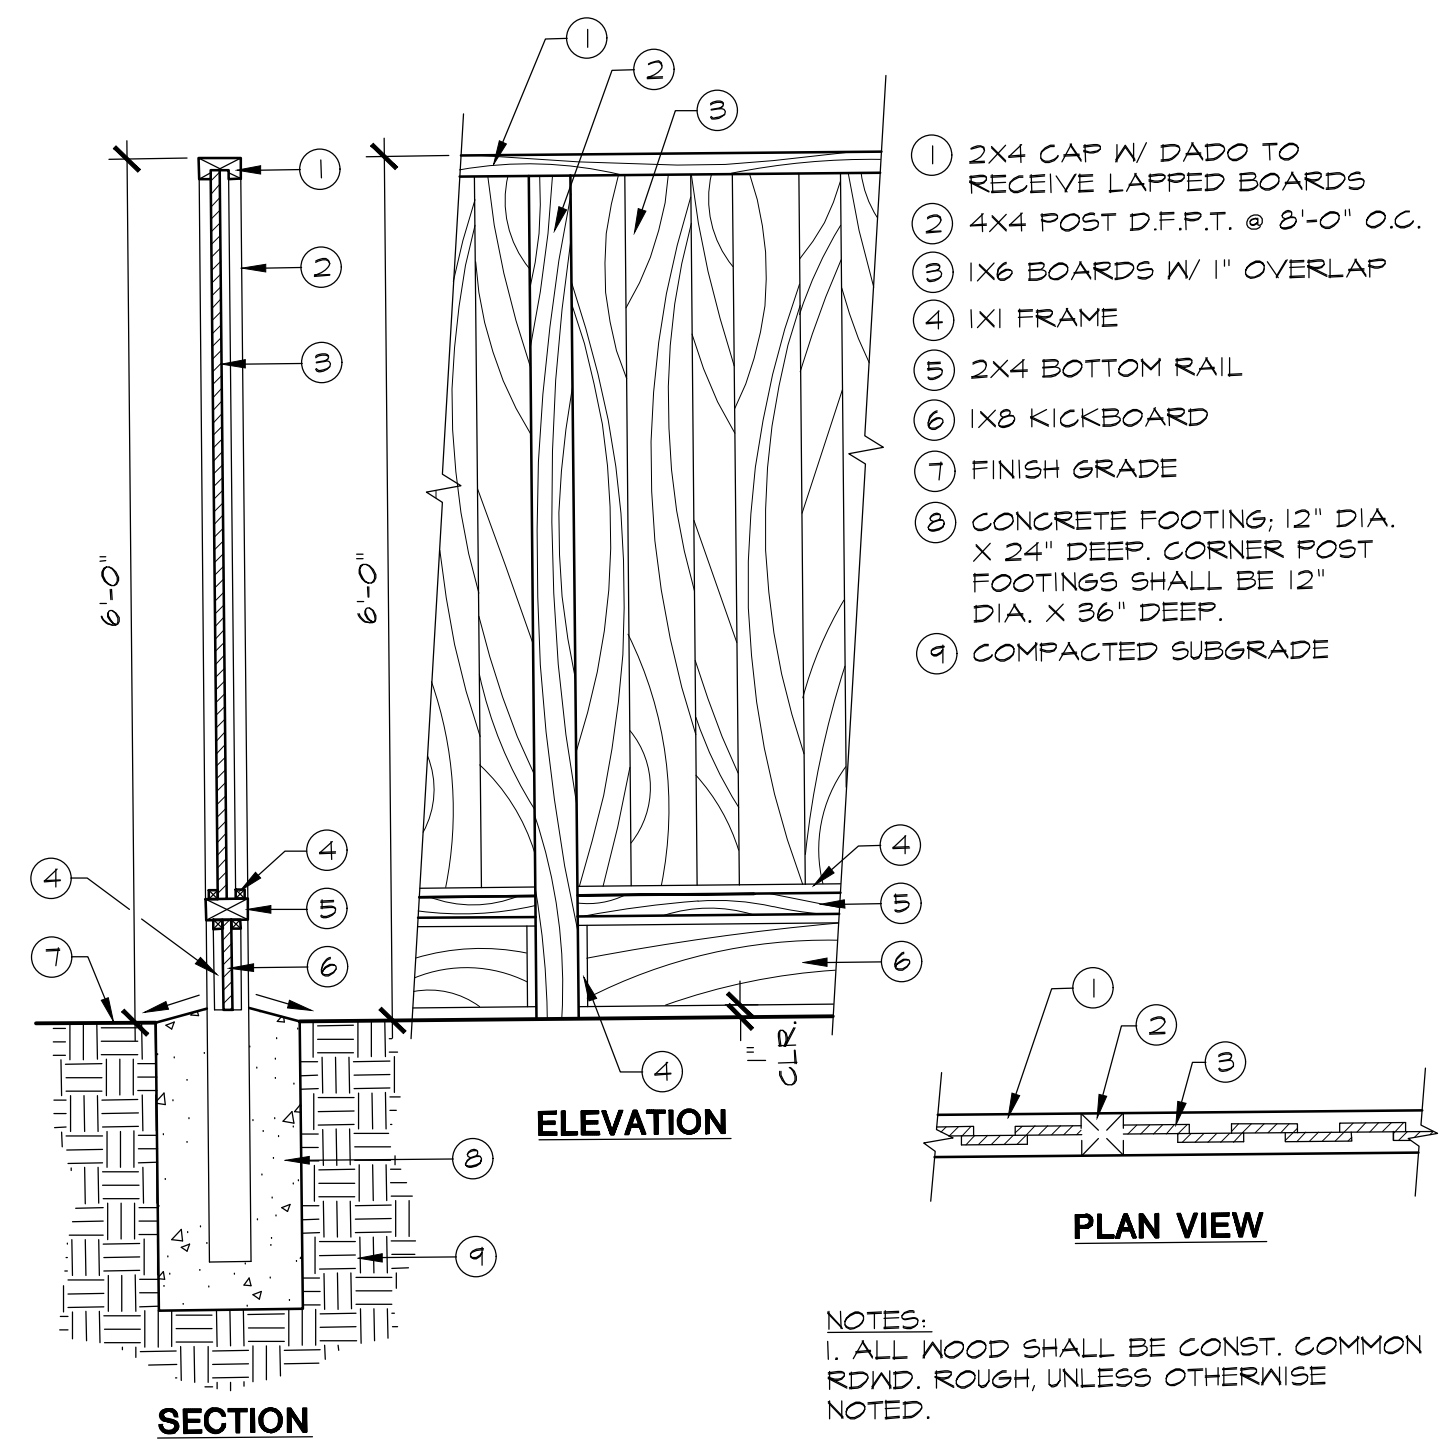


4 6'-0" HT. SOLID WOOD FENCE SCALE: 3/4" = 1'-0"
1/16 DT-FenWood01.dwg

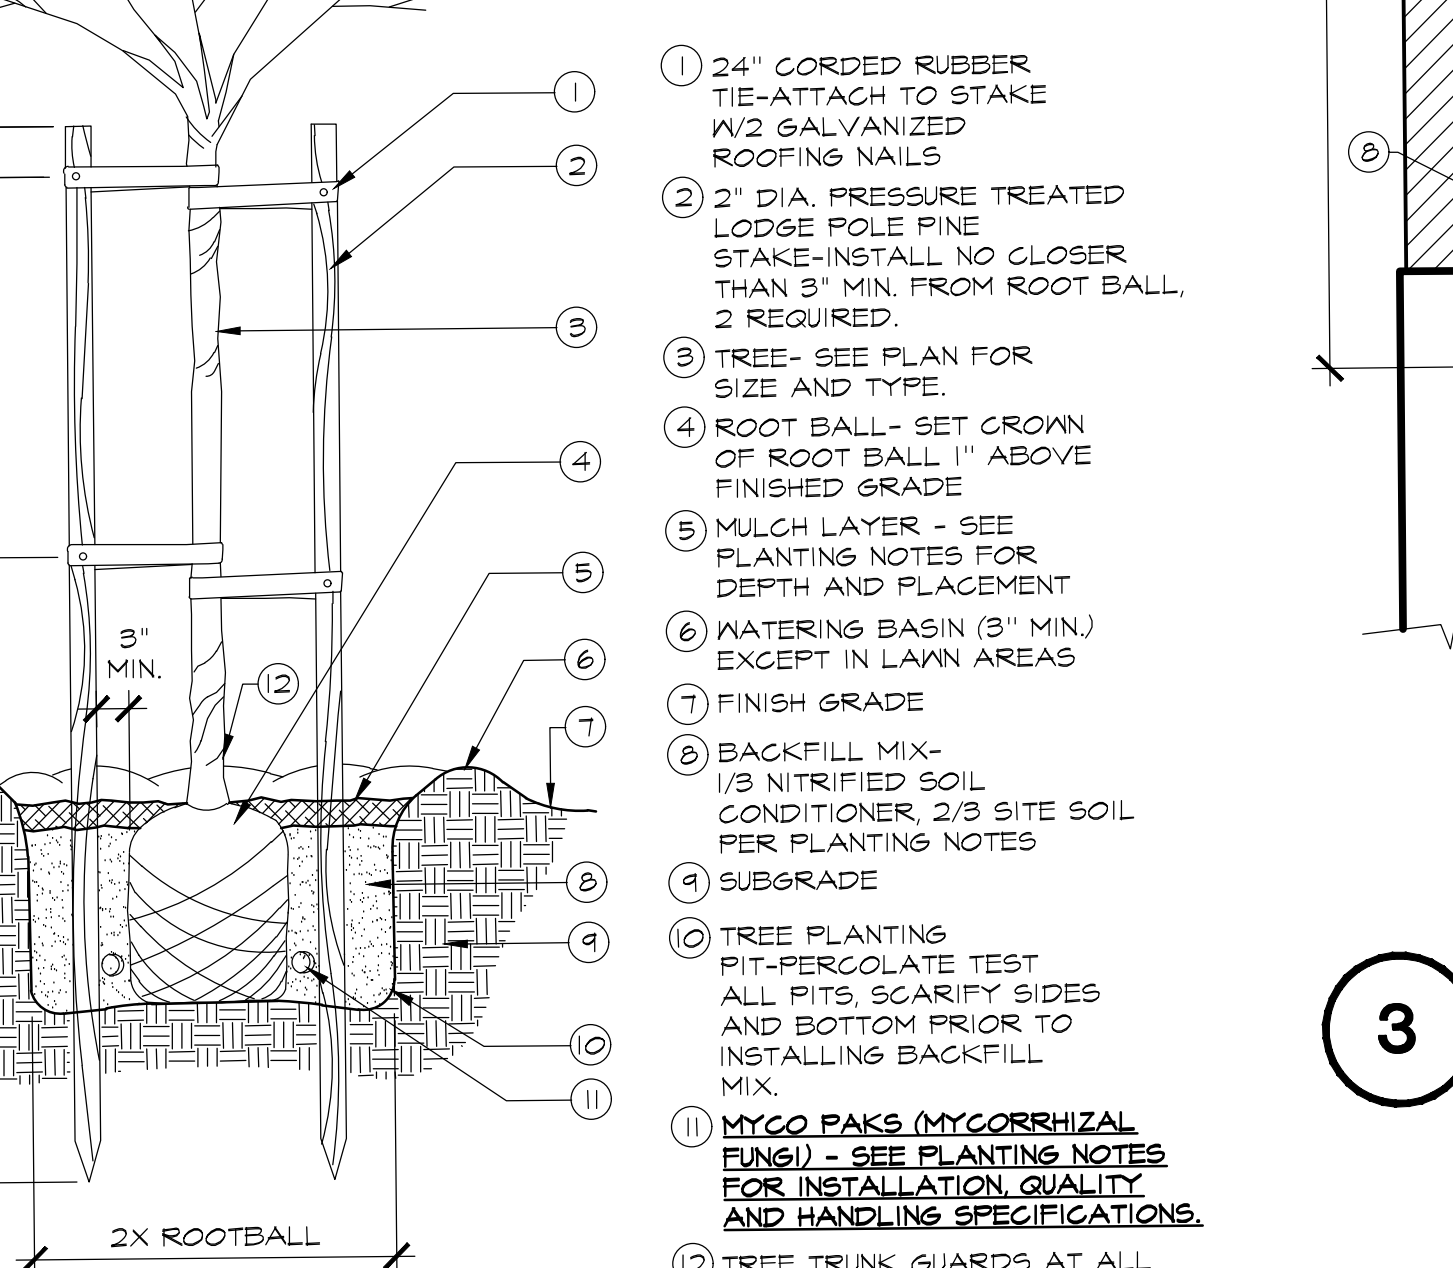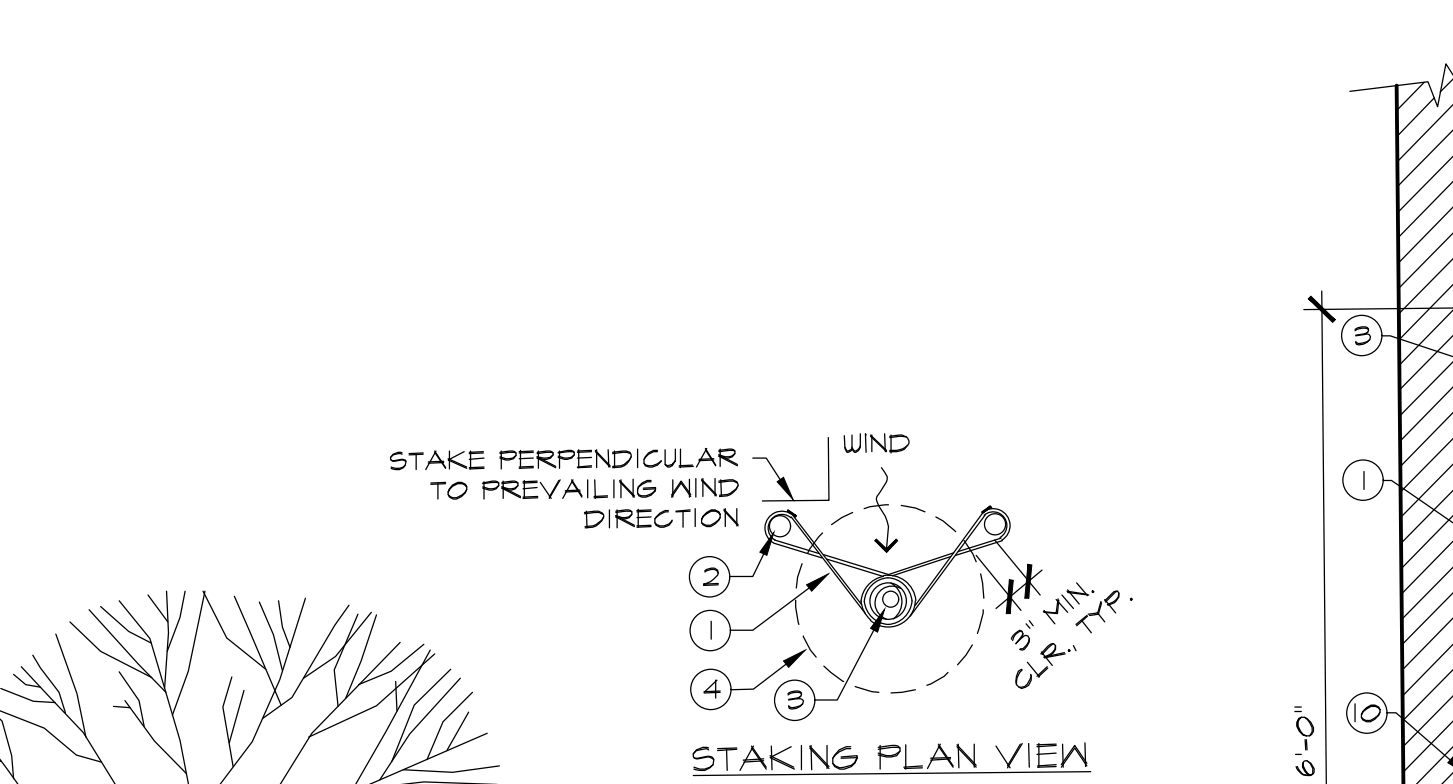


NOTES:
1. SEE PLANTING NOTES AND SPECIFICATIONS FOR ADDITIONAL INFORMATION.


5 TREE PLANTING SCALE: N.T.S.
1/1 DT-Tree-Green02.dwg

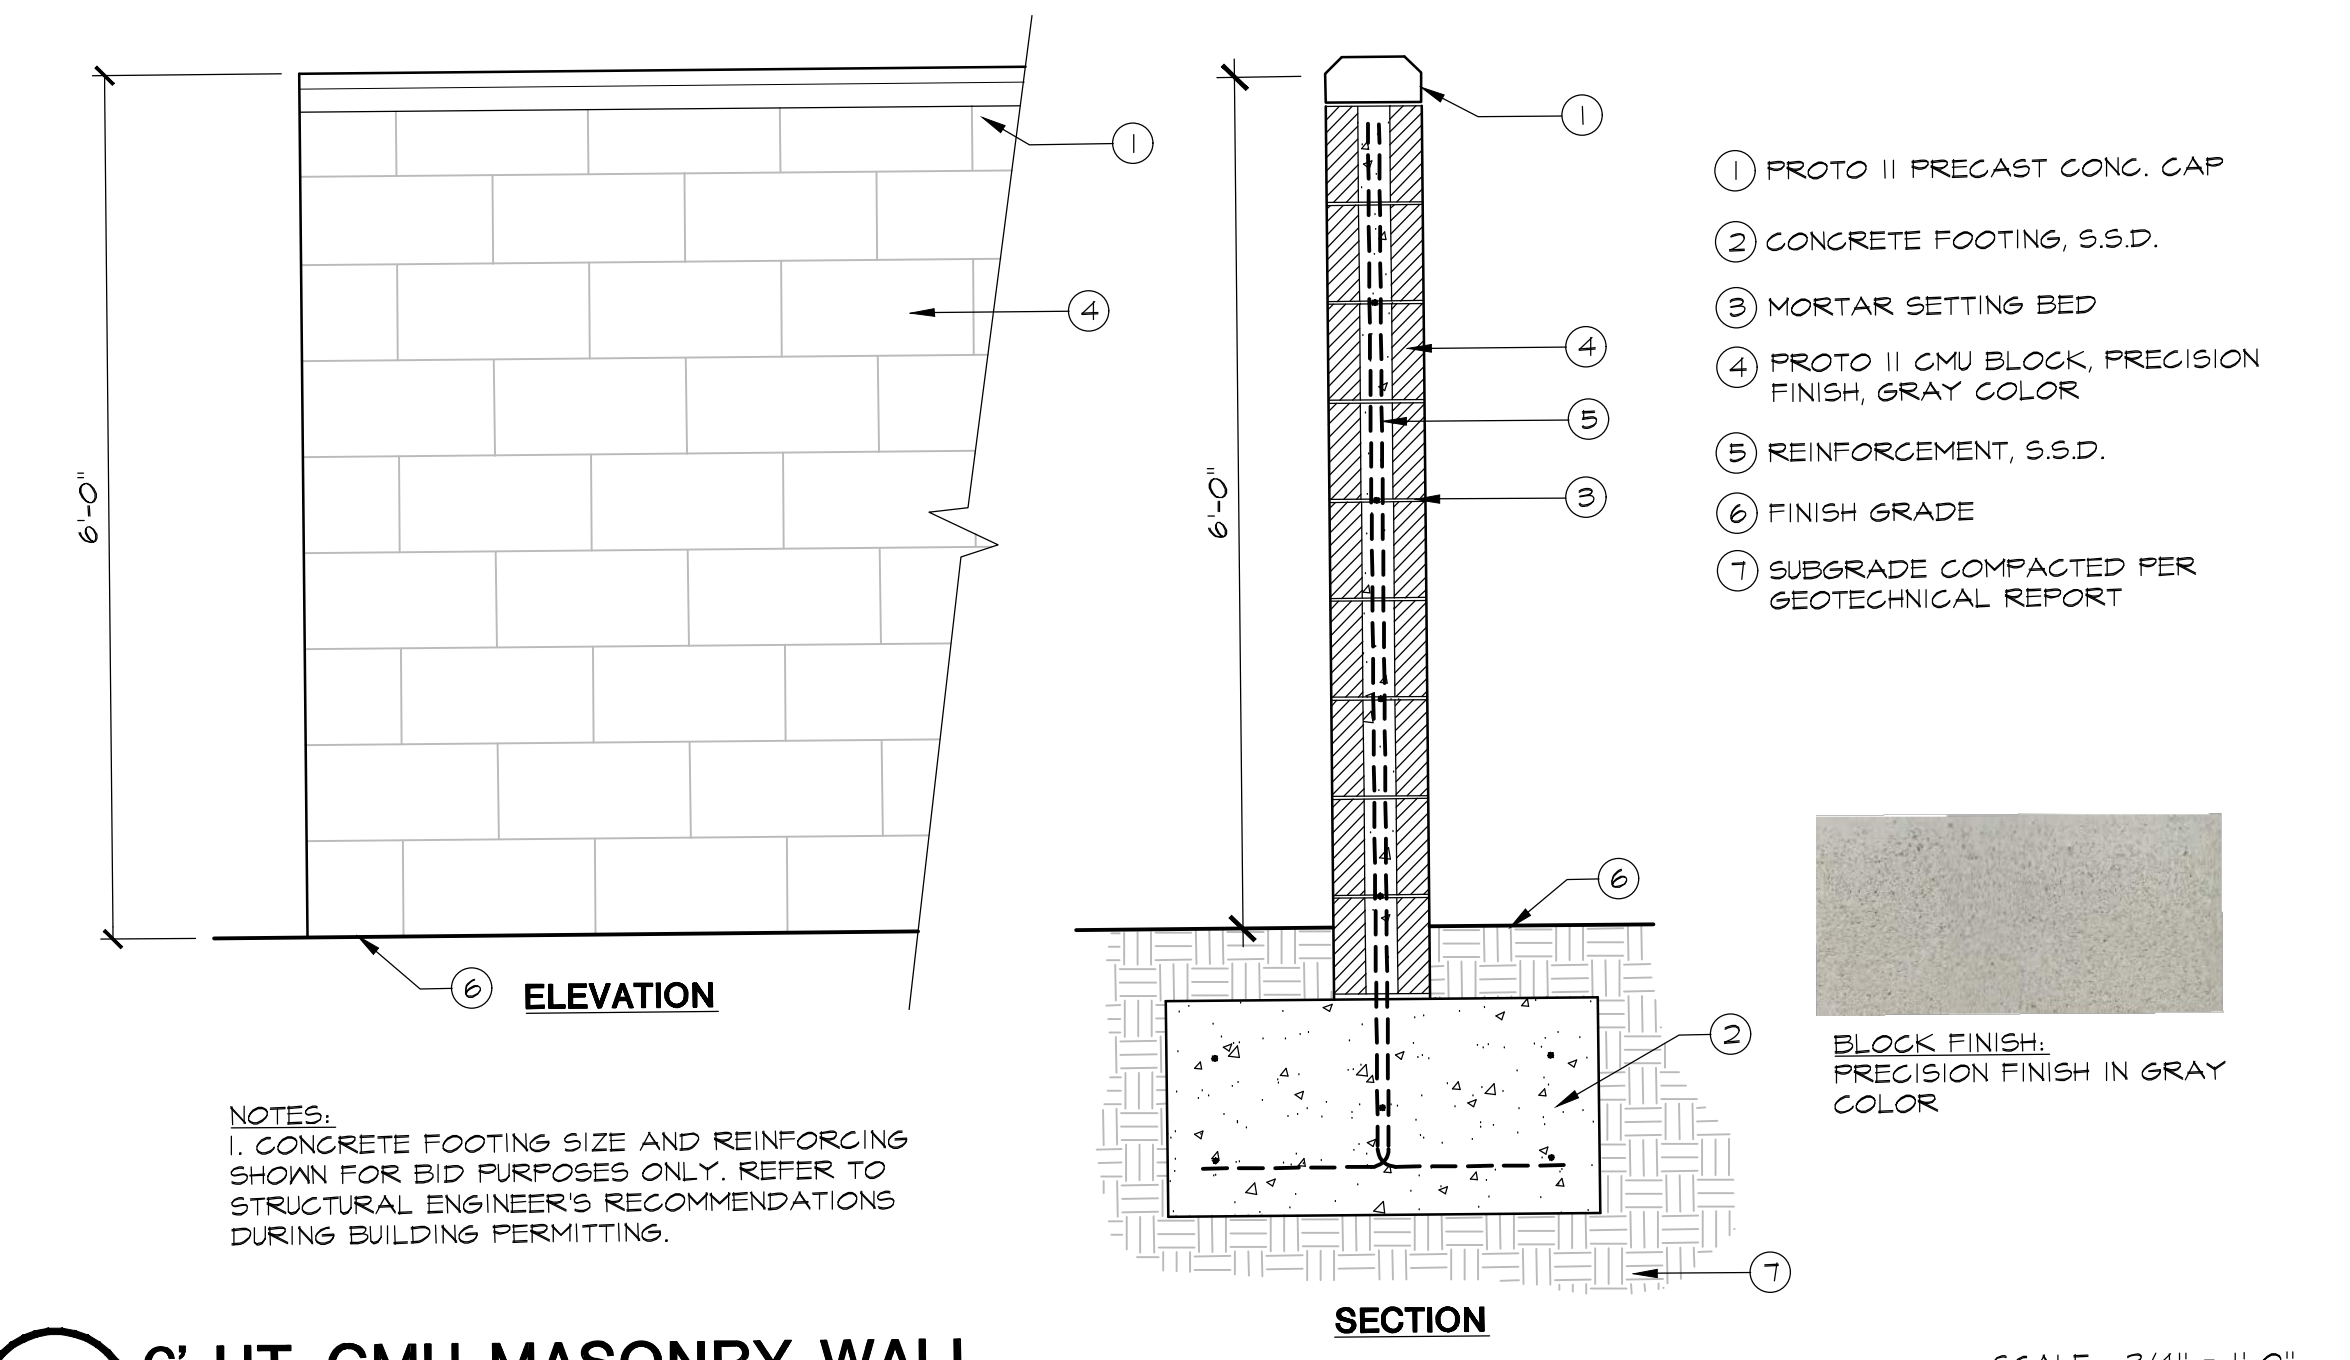

1 6' HT. CMU MASONRY WALL SCALE: 3/4" = 1'-0"
1/16 DT-Wall-CMU.dwg

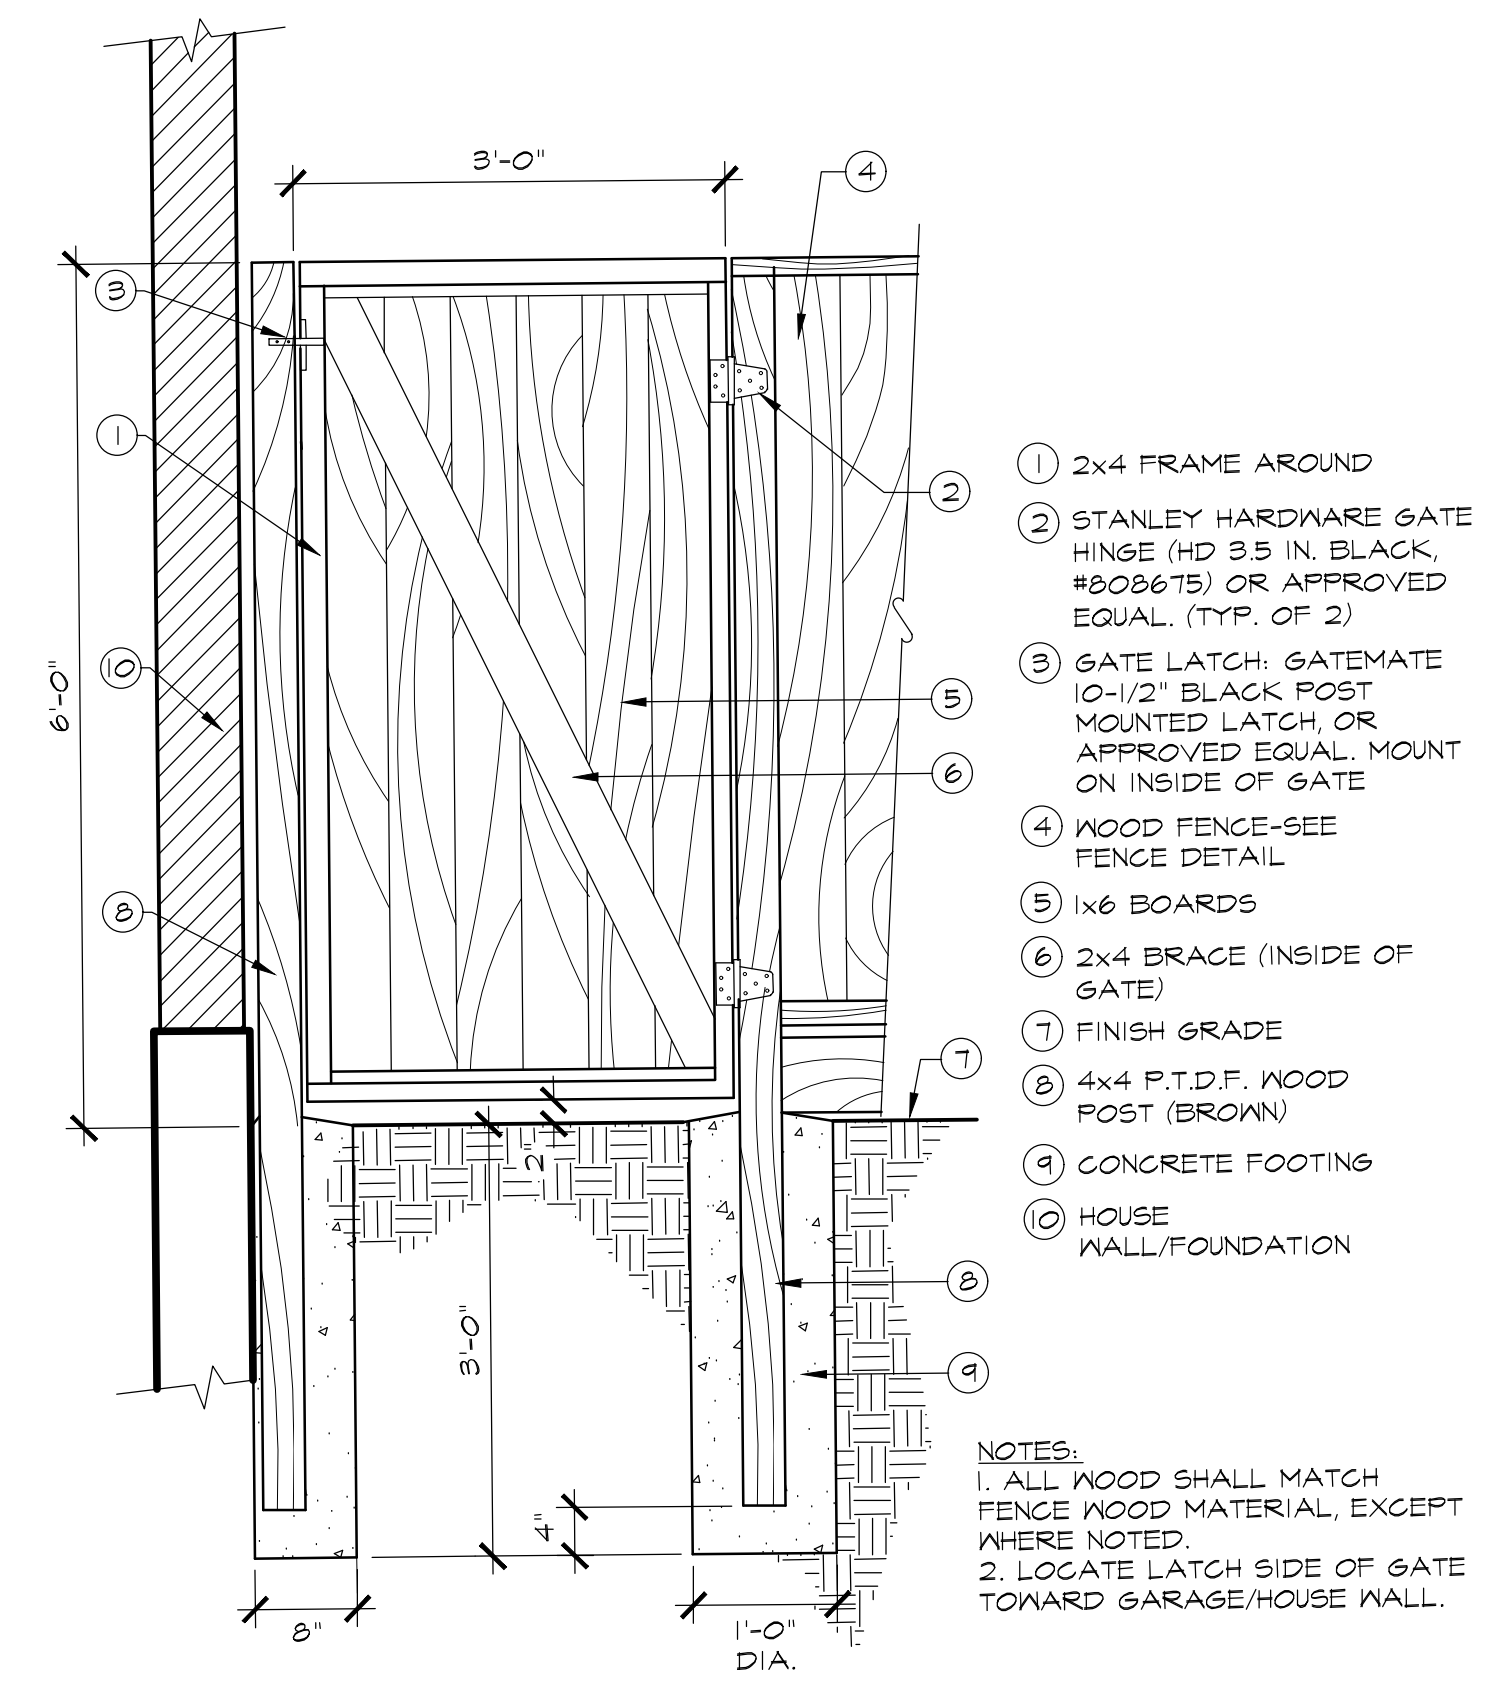


3 6' HT SOLID WOOD GATE SCALE: 3/4" = 1'-0"
1/16 DT-GateWood22.dwg

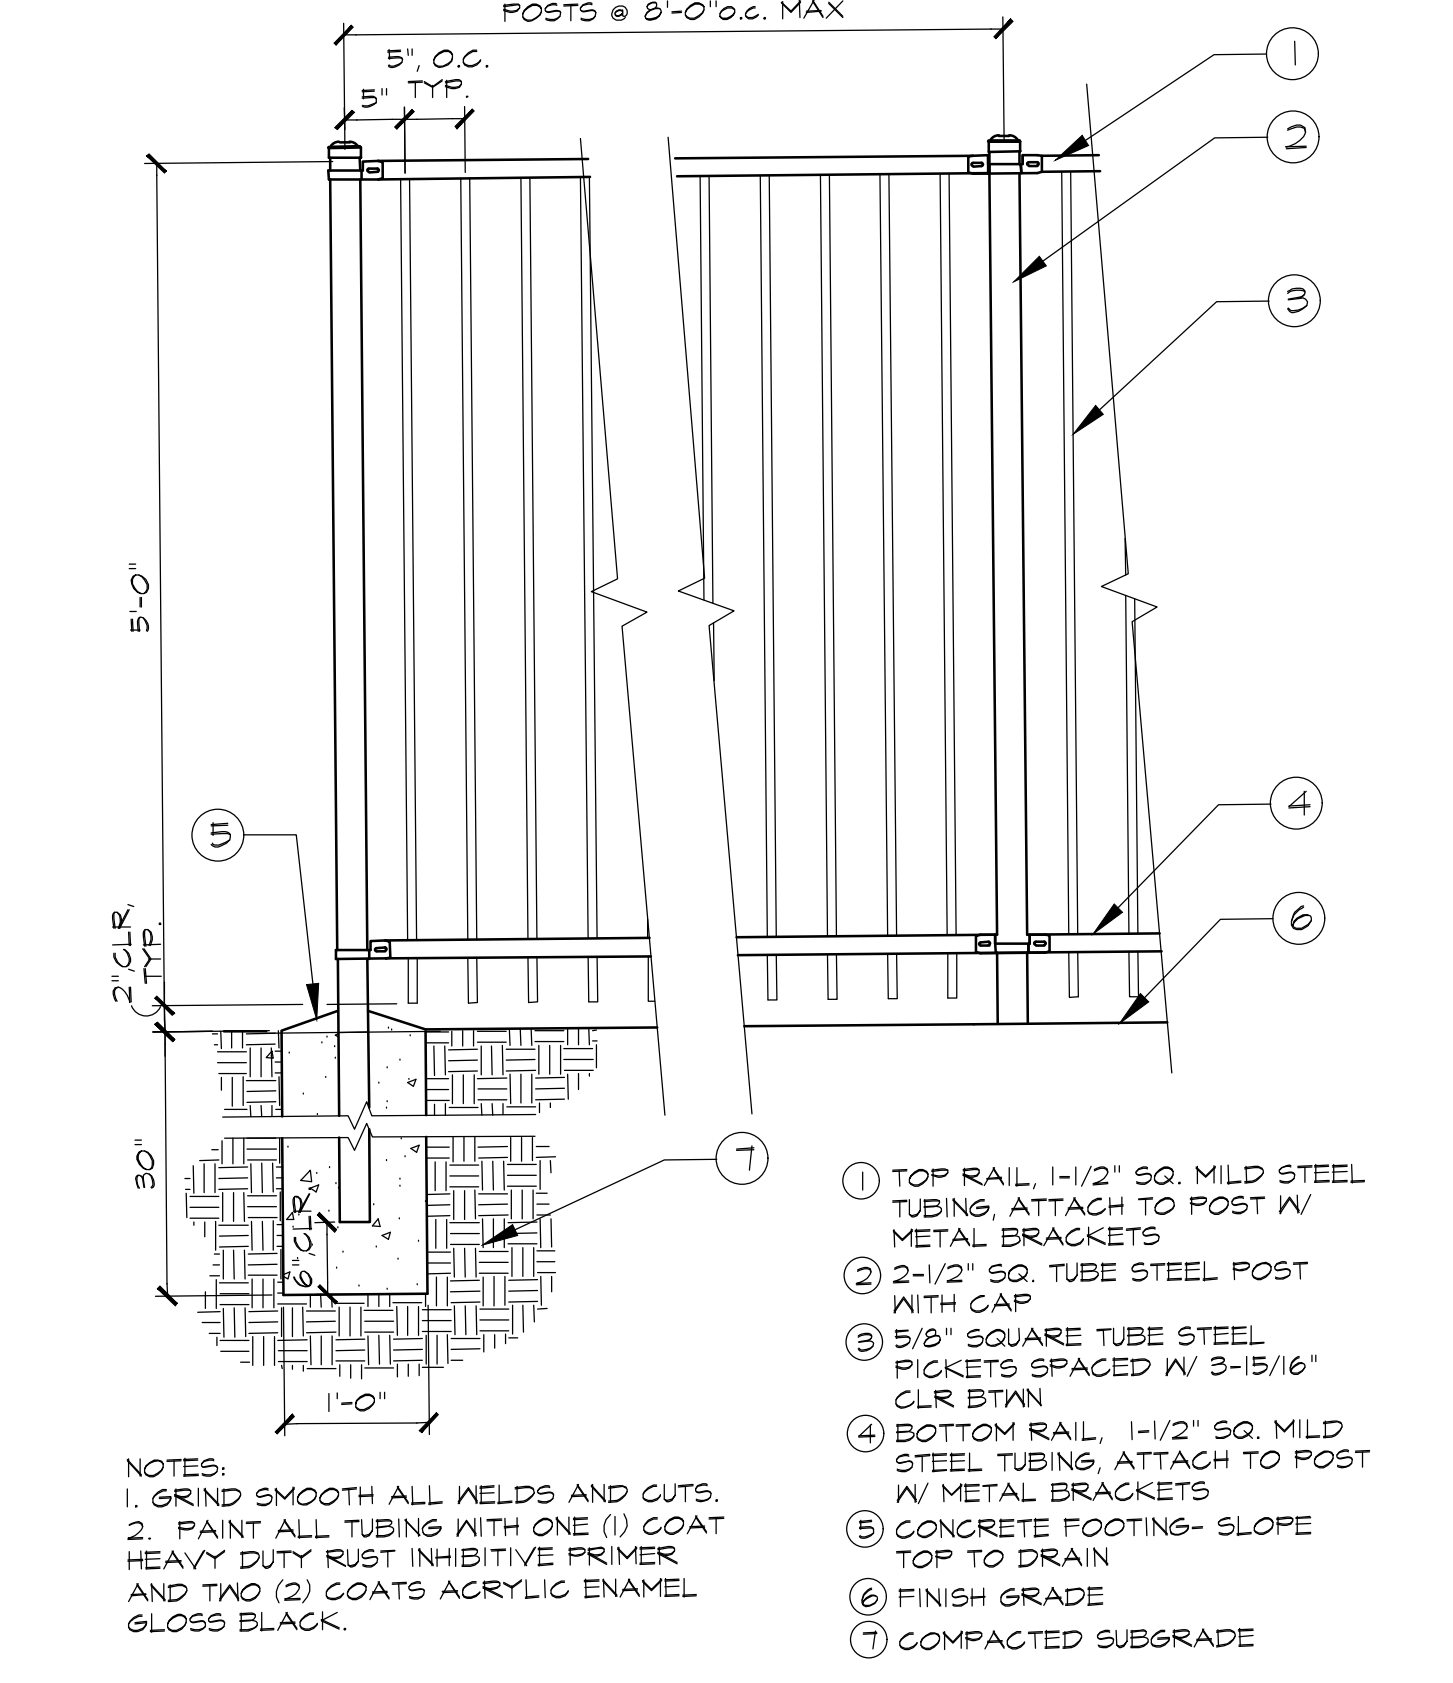

2 5'-0" HT. TUBULAR STEEL FENCE SCALE: 3/4" = 1'-0"
1/16 DT-FenMetal02.dwg

RIALTO PLACE

APN: 076-010-032, 34, 36 & 37
CITY OF ANTIOCH
CONTRA COSTA COUNTY
CALIFORNIA

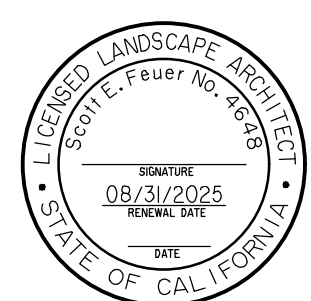

ENVIRONMENTAL
FORESIGHT, INC.
Landscape Architecture
2065 N. Broadway, Suite 203
Walnut Creek, CA 94596
T (925) 945-0300
www.environmentalforesight.com

DATE: 07/23/24
JOB# 23009.01

TENTATIVE MAP: LANDSCAPE DETAILS

NOT FOR CONSTRUCTION

P:\2023\23009.01.dwg(jreiml)_4-Prelim-RP.dwg, 7/23/2024 9:45:11 AM